



STARBUCKS COFFEE

TABLE OF CONTENTS:

- Page S01: Cover Page
- Page S02: Complete Site Plan
- Page S03: Enlarged Site Plan w/ Sign Key
- Page S04: Enlarged Drive Thru Plan 1
- Page S05: Enlarged Drive Thru Plan 2 & 3
- Page S06: North & West Elevations
- Page S07: 60" S/F Logo Disk Cabinet
- Page S08: 48" S/F DRIVE THRU Wall Cab.
- Page S09: 46" D/F DRIVE THRU Directional
- Page S10: 46" D/F EXIT ONLY Directional Sign
- Page S11: 10'-3" Clearance Bar
- Page S12: Pre-Menu Board
- Page S13 & Page S14: Order Point Screen Canopy
- Page S15: 5-Panel Menu Board

Los Angeles Division

10235 BELLEGRAVE AVE.
JURUPA VALLEY, CA 91752
TEL: (909) 923-7668
FAX: (909) 923-5015

© 2018 by YESCO LLC
www.yesco.com
All rights reserved.

CLIENT:



6100 WARNER AVE.
HUNTINGTON BEACH, CA 92647

ACCOUNT EXECUTIVE:

JAY RESAR

DESIGN:

TORK

DATE:

10/30/17

REV./DATE/DESIGNER

R2 / TORK / 08/22/18
Separated ground signs into it's own packet
R3 / TORK / 11/02/18
Added additional signs to complete branding book
R4 / TORK / 11/14/18
Revised per city comments

CUSTOMER APPROVAL:

- Accepted w/o changes
- Accepted w/ changes as noted
- Revise as noted & re-submit

SIGNATURE _____ DATE _____

PRODUCTION APPROVAL:

SALES EXECUTIVE _____ DATE _____

PRODUCTION MGR. _____ DATE _____

This drawing was created to assist you in visualizing our proposal. The original ideas herein are the property of YESCO SIGNS, LLC. Permission to copy or revise this drawing can only be obtained through a written agreement with YESCO. See your sales representative or call the nearest office of YESCO.

This sign is intended to be installed in accordance with the requirements of Article 600 of the National Electrical Code and/or other applicable local codes. This includes proper grounding and bonding of the sign.

Colors represented in this drawing are for presentation only. They cannot match actual processes being used on finished products. All salespersons can reference manufacturer's color charts at your request. Cost of providing necessary wiring to sign area is not included in this sign proposal.

PROJECT NUMBER:

ART 01632 R4

SHEET:

S01

Project #77894-001
Starbucks #0000
WARNER & SPRINGDALE


6100 WARNER AVE.
HUNTINGTON BEACH, CA 92647

TRACT:

LOT:

COUNTY MAP REF #:

APN:

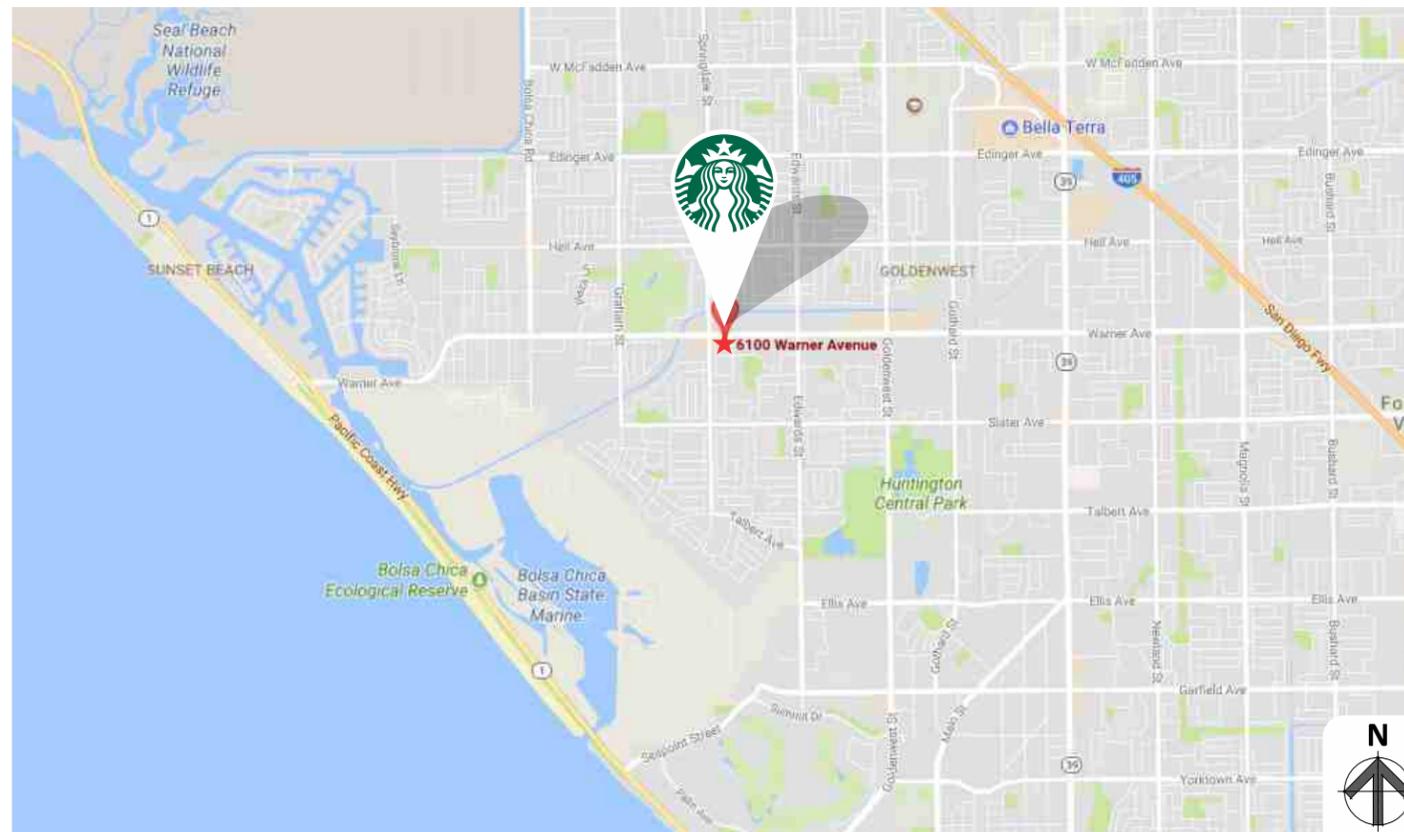

VICINITY MAP

GENERAL NOTES:

All work shall comply with 2013 Edition of CCR Title 24 which adopts and amends the 2012 IBC to 2013 California Building Code, 2013 UMC to 2013 California Mechanical Code, 2013 UPC to 2013 California Plumbing Code, 2008 NEC to 2013 California Electrical Code, 2013 IFC to 2013 California Fire Code and the 2013 Title 24 Energy Efficiency Standards. CBC 1.8.3, LMMC 14.10.010.



This sign is intended to be installed in accordance with the requirements of Article 600 of the National Electrical Code and/or other applicable local codes. This includes proper grounding and bonding of the sign.

NOTE: CUSTOMER TO PROVIDE TITLE 24 COMPLIANT SIGN LIGHTING CONTROLS (AUTOMATIC TIME SWITCH / PHOTO CELL)
CUSTOMER TO PROVIDE PRIMARY POWER TO SIGN LOCATION(S)

DEDICATED SIGN CIRCUITS

SCOPE OF WORK

MANUFACTURE & INSTALL NEW SIGNS INCLUDE:

- Two (2) 60" Logo Disk Cabinets
- Two (2) 48" S/F DRIVE THRU Wall Cabinets
- One (1) 46" D/F DRIVE THRU Directional Sign
- One (1) 46" D/F EXIT ONLY Directional Sign
- One (1) 10'-3" Clearance Bar

SHIP-IN & INSTALL:

- One (1) Pre-Menu Board
- One (1) Digital Order Screen & Canopy
- One (1) 5-Panel Menu Board

Los Angeles Division

10235 BELLEGRAVE AVE.
 JURUPA VALLEY, CA 91752
 TEL: (909) 923-7668
 FAX: (909) 923-5015

© 2018 by YESCO LLC
 www.yesco.com
 All rights reserved.

CLIENT:



6100 WARNER AVE.
 HUNTINGTON BEACH, CA 92647

ACCOUNT EXECUTIVE:

JAY RESAR

DESIGN:

TORK

DATE:

10/30/17

REV./DATE/DESIGNER

R2 / TORK / 08/22/18
 Separated ground signs into it's own packet
 R3 / TORK / 11/02/18
 Added additional signs to complete branding book
 R4 / TORK / 11/14/18
 Revised per city comments

CUSTOMER APPROVAL:

- Accepted w/o changes
- Accepted w/ changes as noted
- Revise as noted & re-submit

SIGNATURE _____ DATE _____

PRODUCTION APPROVAL:

SALES EXECUTIVE _____ DATE _____

PRODUCTION MGR. _____ DATE _____

This drawing was created to assist you in visualizing our proposal. The original ideas herein are the property of YESCO SIGNS, LLC. Permission to copy or revise this drawing can only be obtained through a written agreement with YESCO. See your sales representative or call the nearest office of YESCO.

This sign is intended to be installed in accordance with the requirements of Article 600 of the National Electrical Code and/or other applicable local codes. This includes proper grounding and bonding of the sign.



Colors represented in this drawing are for presentation only. They cannot match actual processes being used on finished products. All salespersons can reference manufacturer's color charts at your request. Cost of providing necessary wiring to sign area is not included in this sign proposal.

PROJECT NUMBER:

ART 01632 R4

SHEET:

S02

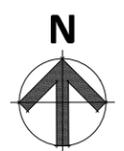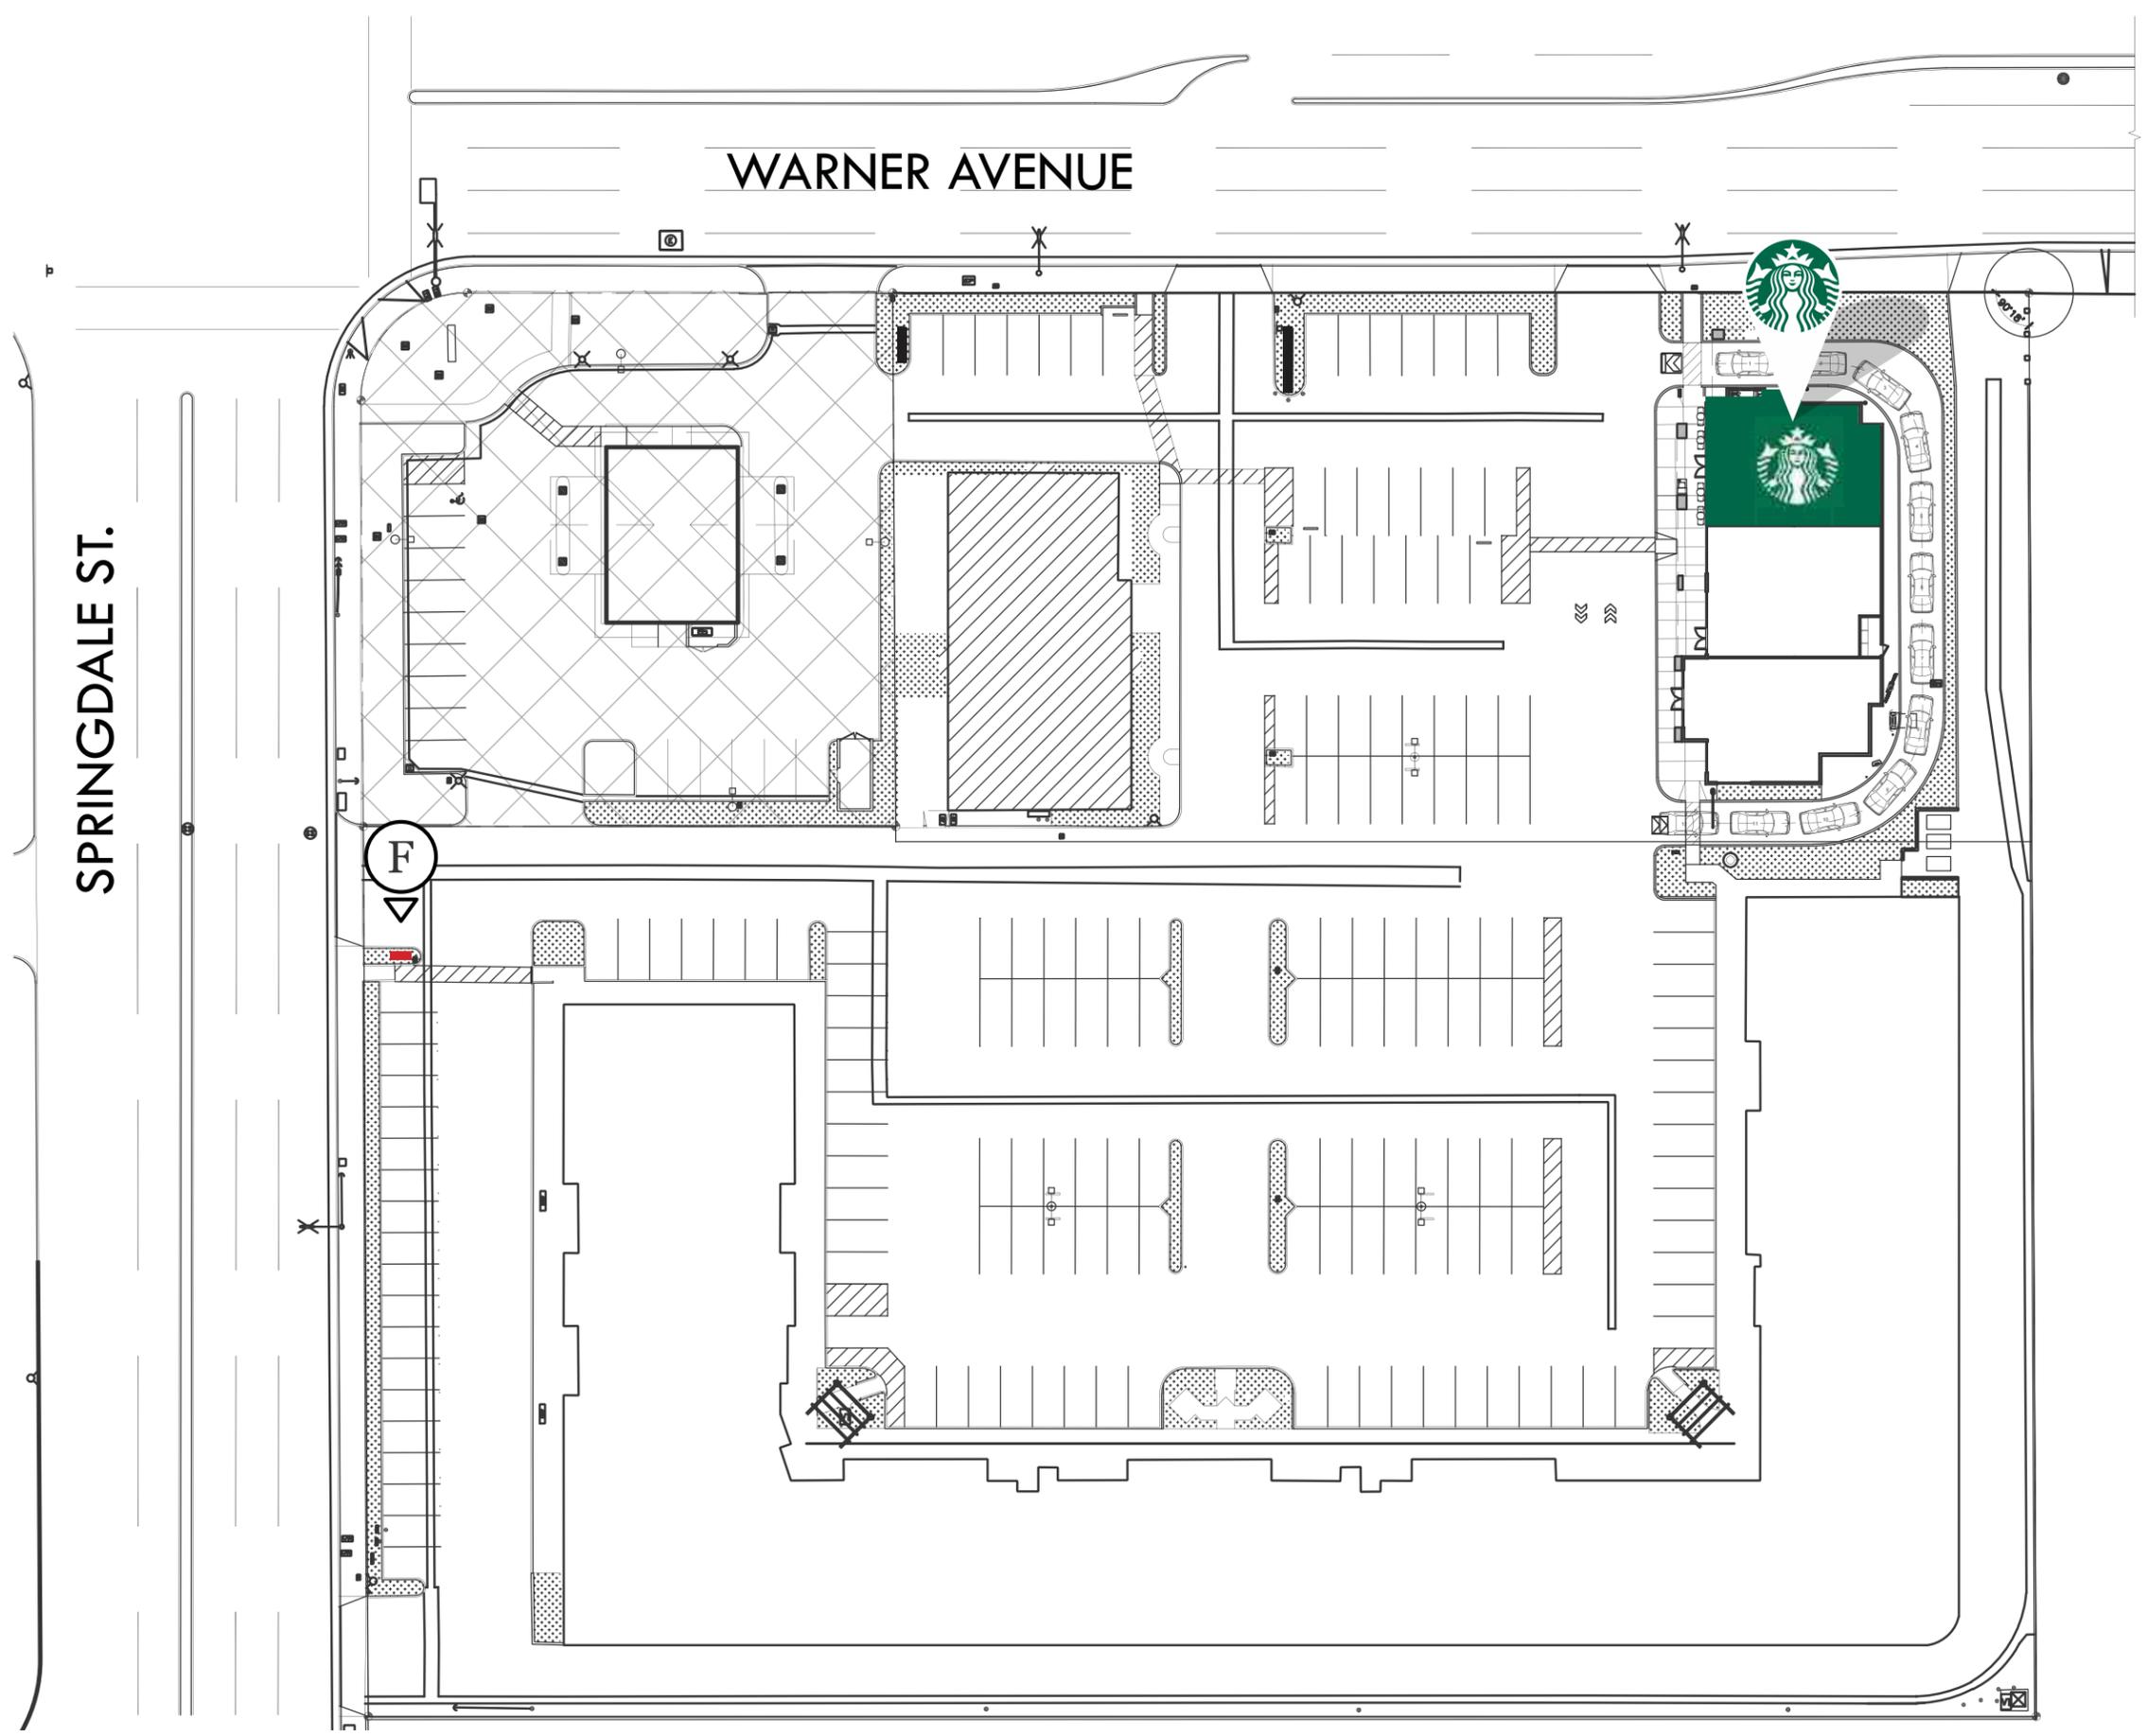


SITE PLAN
 SCALE: 1" = 25'-0"

MANUFACTURE & INSTALL

SIGN	DESCRIPTION	DESIGN #	QUANT	SQ.FT. (ea)	TOTAL
A1 A2	 60" LOGO DISK CAB.	<i>*Custom*</i>	2	19.62	39.24
B1 B2	 48" DRIVE-THRU ARROW SERIES (RH)	14099	2	6.96	13.92
C	 "DRIVE THRU" DIRECTIONAL	14104 <i>*Custom*</i>	1	1.51	1.51
D	 "EXIT ONLY" DIRECTIONAL	14091	1	0.94	0.94
E	 CLEARANCE BAR	14106	1	2.3	2.3

SHIP-IN & INSTALL ONLY

SIGN	DESCRIPTION	DESIGN #	QUANT	SQ.FT. (ea)	TOTAL
F	 PRE-MENU	14120	1	12.0	12.0
G	 ORDER POINT w/ CANOPY	14163 (Canopy) 14116 (Screen)	1	N/A	N/A
H	 MENU BOARD	14119	1	36.0	36.0

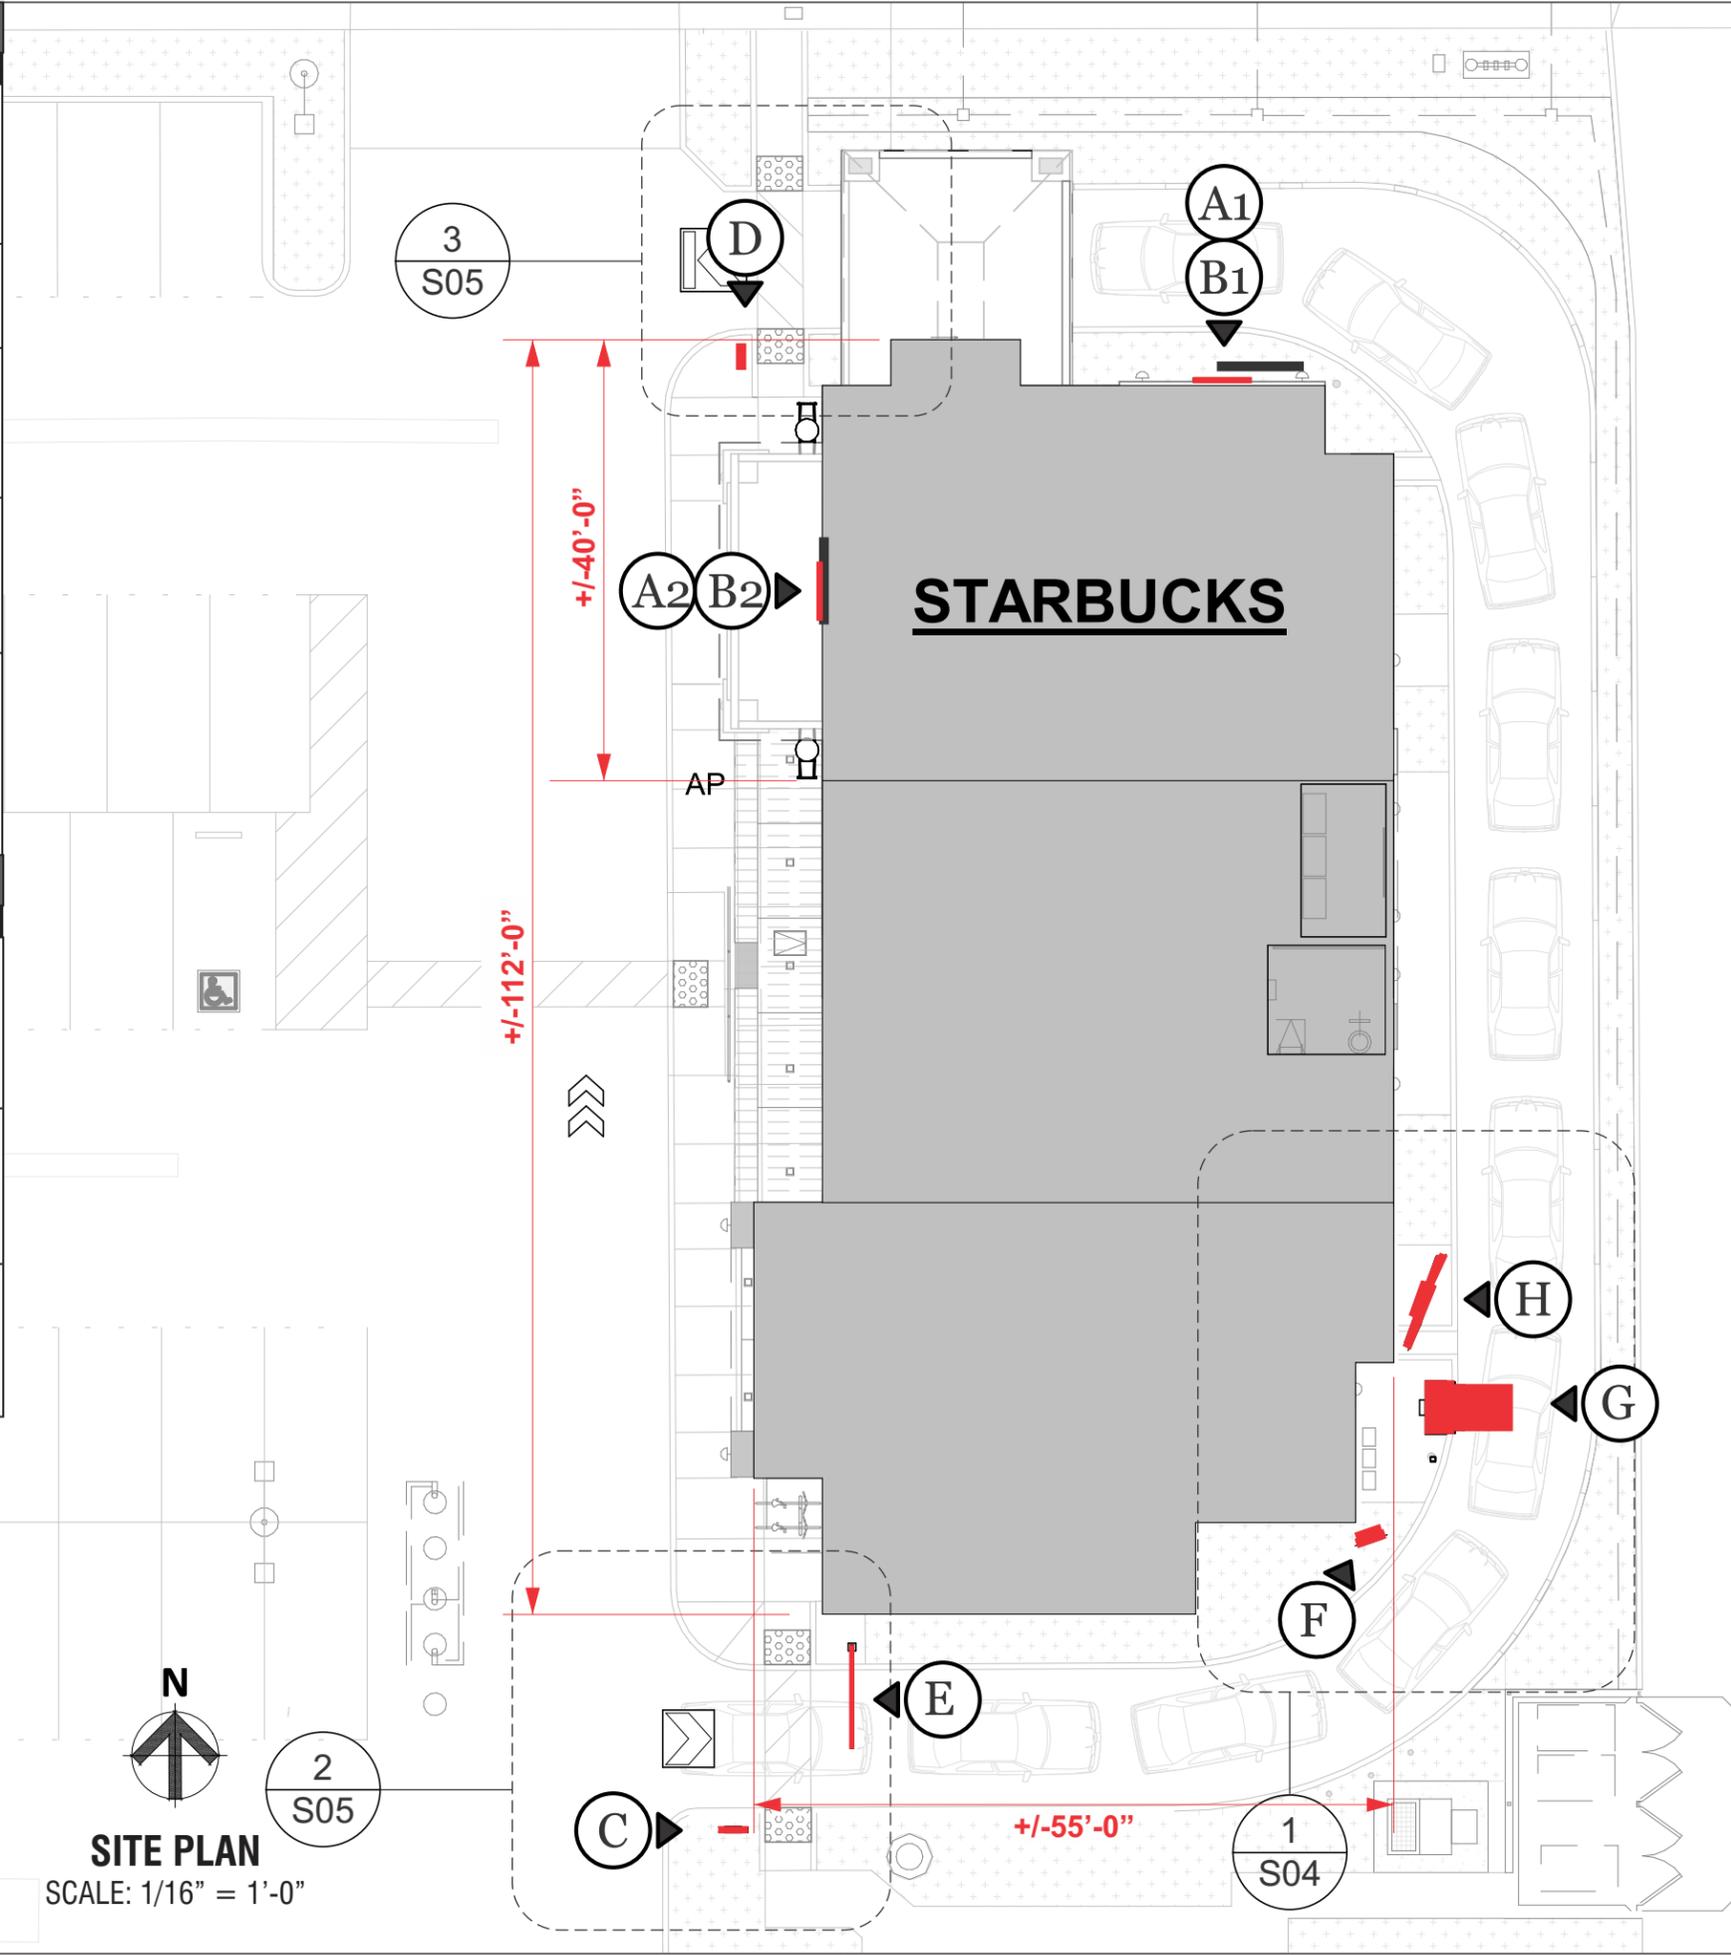

SITE PLAN
SCALE: 1/16" = 1'-0"



CALIFORNIA CONTRACTOR LICENSE NO. 980698

Los Angeles Division

10235 BELLEGRAVE AVE.
JURUPA VALLEY, CA 91752
TEL: (909) 923-7668
FAX: (909) 923-5015

© 2018 by YESCO LLC
www.yesco.com
All rights reserved.

CLIENT:



6100 WARNER AVE.
HUNTINGTON BEACH, CA 92647

ACCOUNT EXECUTIVE:

JAY RESAR

DESIGN:

TORK

DATE:

10/30/17

REV./DATE/DESIGNER

R2 / TORK / 08/22/18
Separated ground signs into it's own packet
R3 / TORK / 11/02/18
Added additional signs to complete branding book
R4 / TORK / 11/14/18
Revised per city comments

CUSTOMER APPROVAL:

- Accepted w/o changes
- Accepted w/ changes as noted
- Revise as noted & re-submit

SIGNATURE _____ DATE _____

PRODUCTION APPROVAL:

SALES EXECUTIVE _____ DATE _____

PRODUCTION MGR. _____ DATE _____

This drawing was created to assist you in visualizing our proposal. The original ideas herein are the property of YESCO SIGNS, LLC. Permission to copy or revise this drawing can only be obtained through a written agreement with YESCO. See your sales representative or call the nearest office of YESCO.

This sign is intended to be installed in accordance with the requirements of Article 600 of the National Electrical Code and/or other applicable local codes. This includes proper grounding and bonding of the sign.

Colors represented in this drawing are for presentation only. They cannot match actual processes being used on finished products. All salespersons can reference manufacturer's color charts at your request. Cost of providing necessary wiring to sign area is not included in this sign proposal.

PROJECT NUMBER:

ART 01632 R4

SHEET:

S03

Los Angeles Division

10235 BELLEGRAVE AVE.
 JURUPA VALLEY, CA 91752
 TEL: (909) 923-7668
 FAX: (909) 923-5015

© 2018 by YESCO LLC
 www.yesco.com
 All rights reserved.

CLIENT:



6100 WARNER AVE.
 HUNTINGTON BEACH, CA 92647

ACCOUNT EXECUTIVE:

JAY RESAR

DESIGN:

TORK

DATE:

10/30/17

REV./DATE/DESIGNER

R2 / TORK / 08/22/18
 Separated ground signs into it's own packet
 R3 / TORK / 11/02/18
 Added additional signs to complete branding book
 R4 / TORK / 11/14/18
 Revised per city comments

CUSTOMER APPROVAL:

- Accepted w/o changes
- Accepted w/ changes as noted
- Revise as noted & re-submit

SIGNATURE _____ DATE _____

PRODUCTION APPROVAL:

SALES EXECUTIVE _____ DATE _____

PRODUCTION MGR. _____ DATE _____

This drawing was created to assist you in visualizing our proposal. The original ideas herein are the property of YESCO SIGNS, LLC. Permission to copy or revise this drawing can only be obtained through a written agreement with YESCO. See your sales representative or call the nearest office of YESCO.

This sign is intended to be installed in accordance with the requirements of Article 600 of the National Electrical Code and/or other applicable local codes. This includes proper grounding and bonding of the sign.


Colors represented in this drawing are for presentation only. They cannot match actual processes being used on finished products. All salespersons can reference manufacturer's color charts at your request. Cost of providing necessary wiring to sign area is not included in this sign proposal.

PROJECT NUMBER:

ART 01632 R4

SHEET:

S04

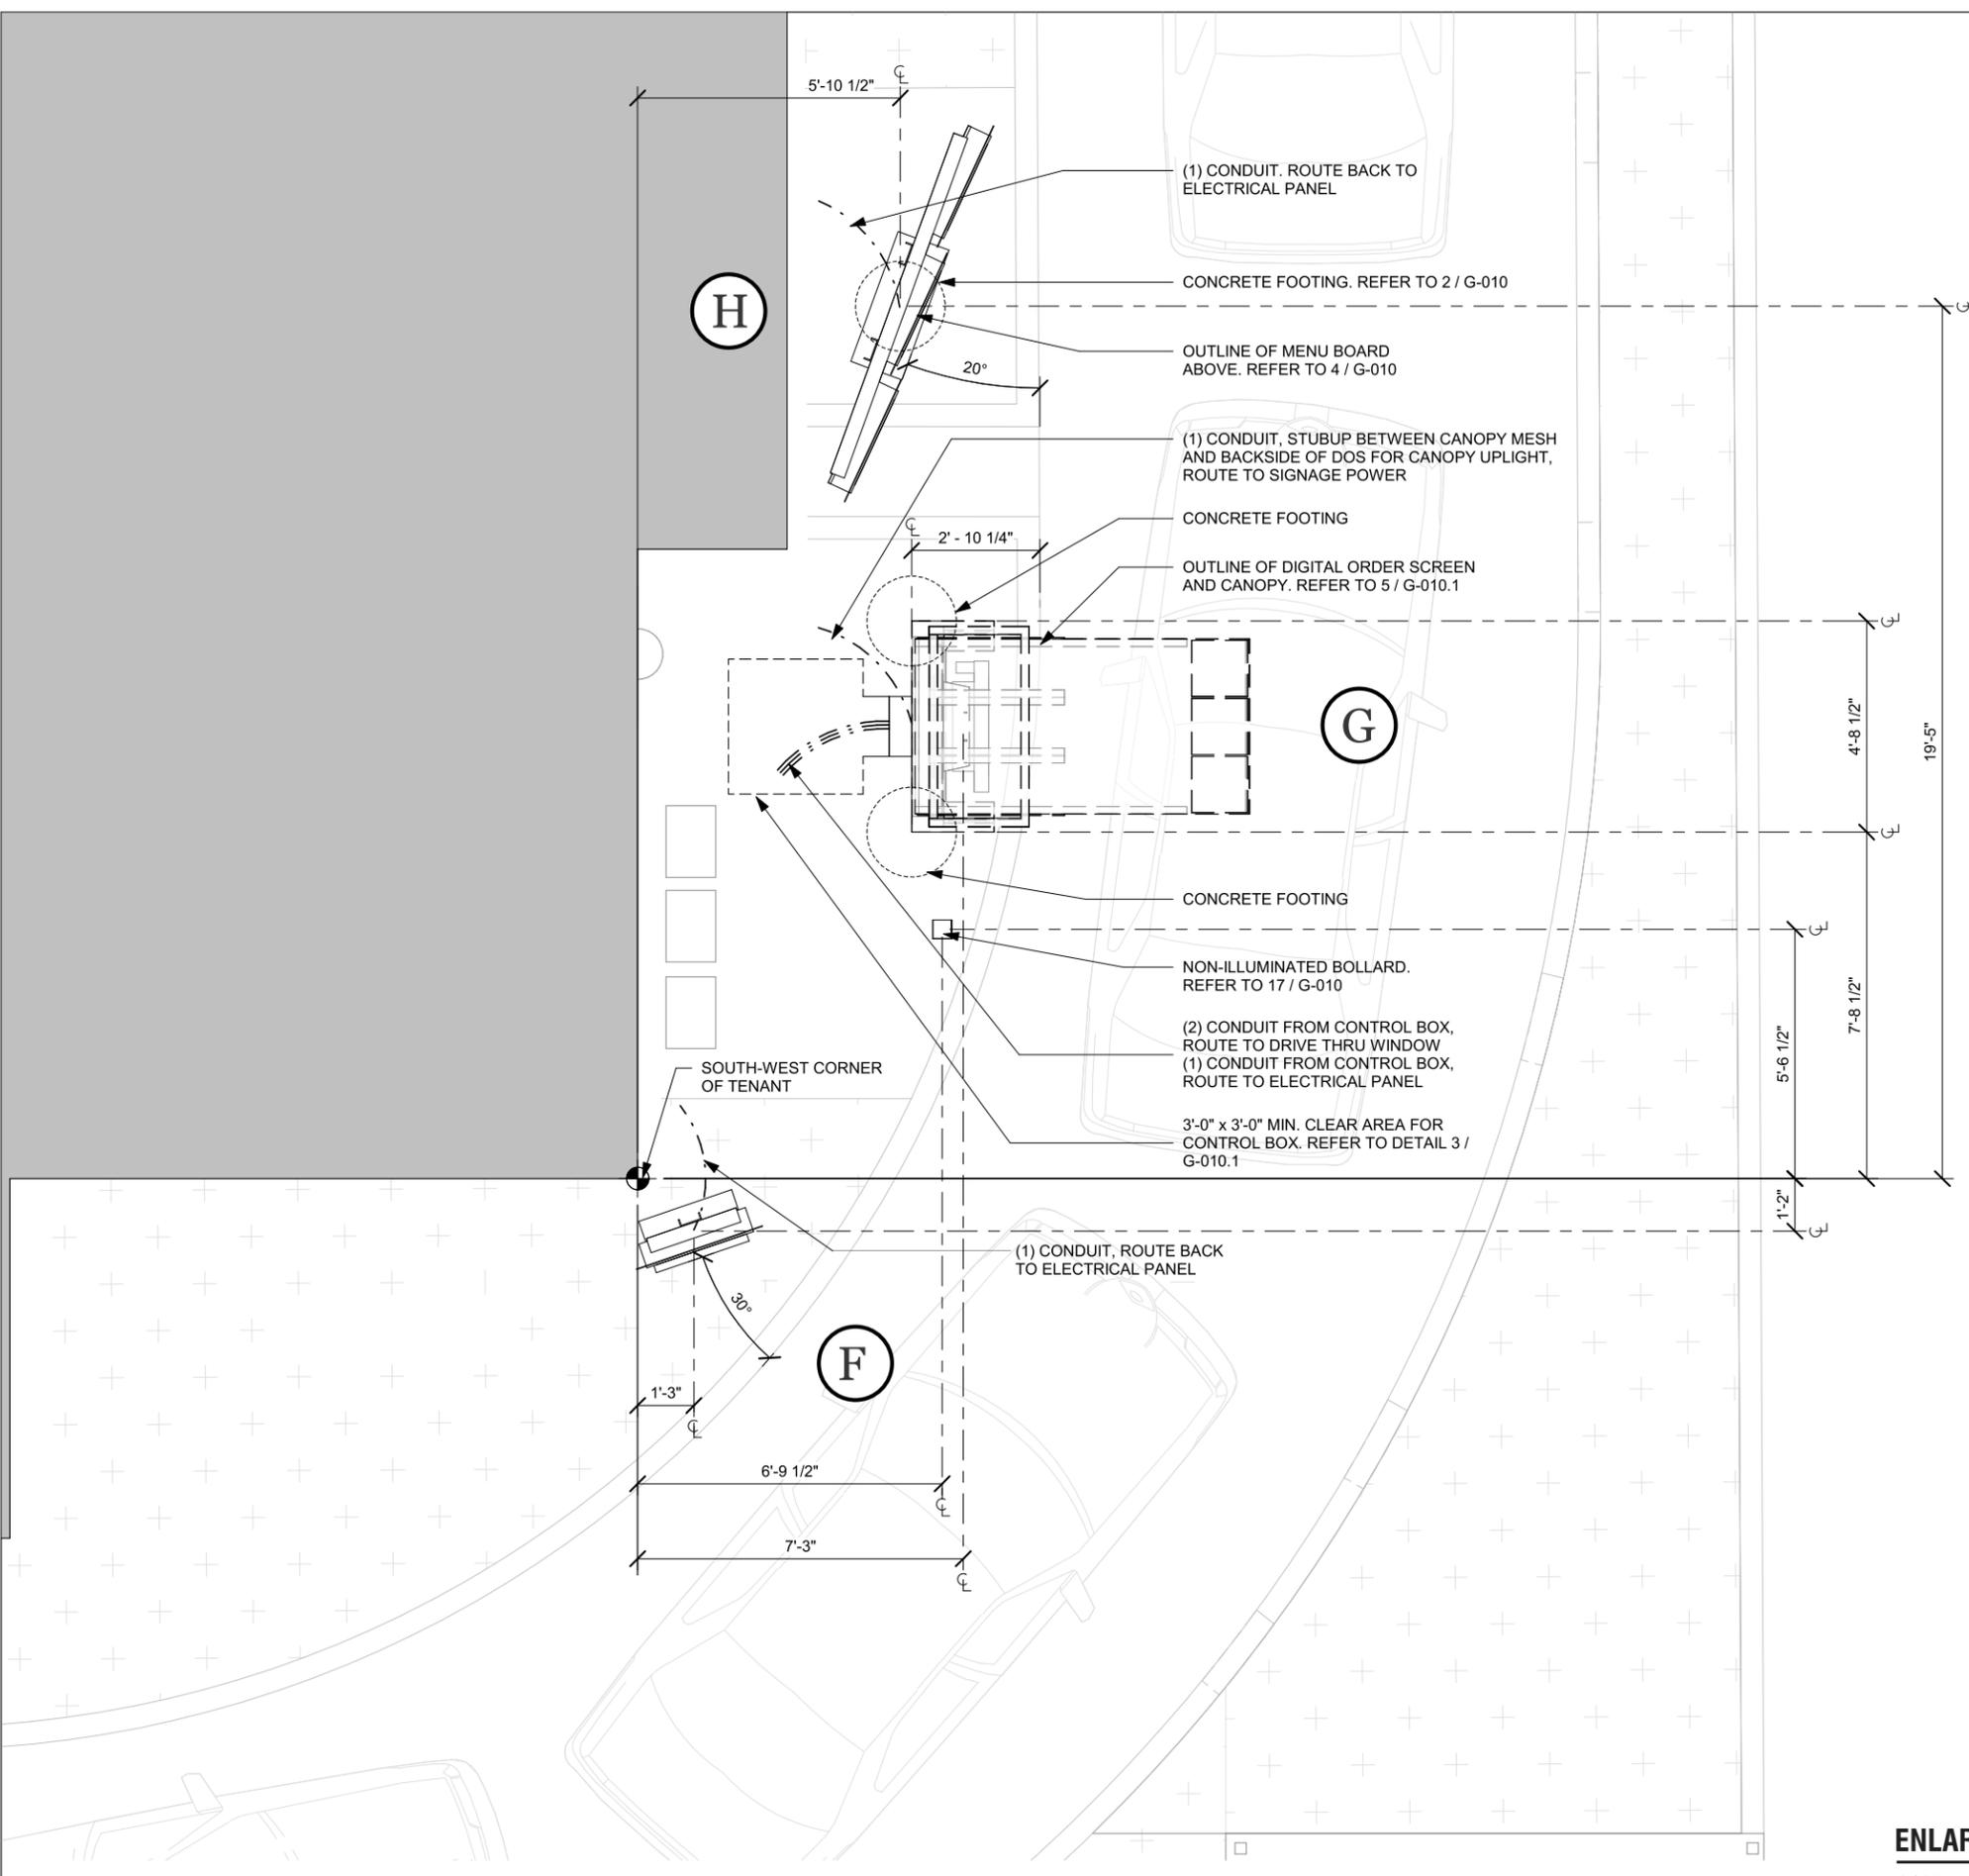

ENLARGED DRIVE PLAN 1

1/4" = 1'-0" SCALE

Los Angeles Division

10235 BELLEGRAVE AVE.
JURUPA VALLEY, CA 91752
TEL: (909) 923-7668
FAX: (909) 923-5015

© 2018 by YESCO LLC
www.yesco.com
All rights reserved.

CLIENT:



6100 WARNER AVE.
HUNTINGTON BEACH, CA 92647

ACCOUNT EXECUTIVE:

JAY RESAR

DESIGN:

TORK

DATE:

10/30/17

REV./DATE/DESIGNER

R2 / TORK / 08/22/18
Separated ground signs into it's own packet
R3 / TORK / 11/02/18
Added additional signs to complete branding book
R4 / TORK / 11/14/18
Revised per city comments

CUSTOMER APPROVAL:

- Accepted w/o changes
- Accepted w/ changes as noted
- Revise as noted & re-submit

SIGNATURE _____ DATE _____

PRODUCTION APPROVAL:

SALES EXECUTIVE _____ DATE _____
PRODUCTION MGR. _____ DATE _____

This drawing was created to assist you in visualizing our proposal. The original ideas herein are the property of YESCO SIGNS, LLC. Permission to copy or revise this drawing can only be obtained through a written agreement with YESCO. See your sales representative or call the nearest office of YESCO.

This sign is intended to be installed in accordance with the requirements of Article 600 of the National Electrical Code and/or other applicable local codes. This includes proper grounding and bonding of the sign.

Colors represented in this drawing are for presentation only. They cannot match actual processes being used on finished products. All salespersons can reference manufacturer's color charts at your request. Cost of providing necessary wiring to sign area is not included in this sign proposal.

PROJECT NUMBER:



ART 01632 R4

SHEET:

S05

ENLARGED DRIVE PLAN 3

1/4" = 1'-0" SCALE

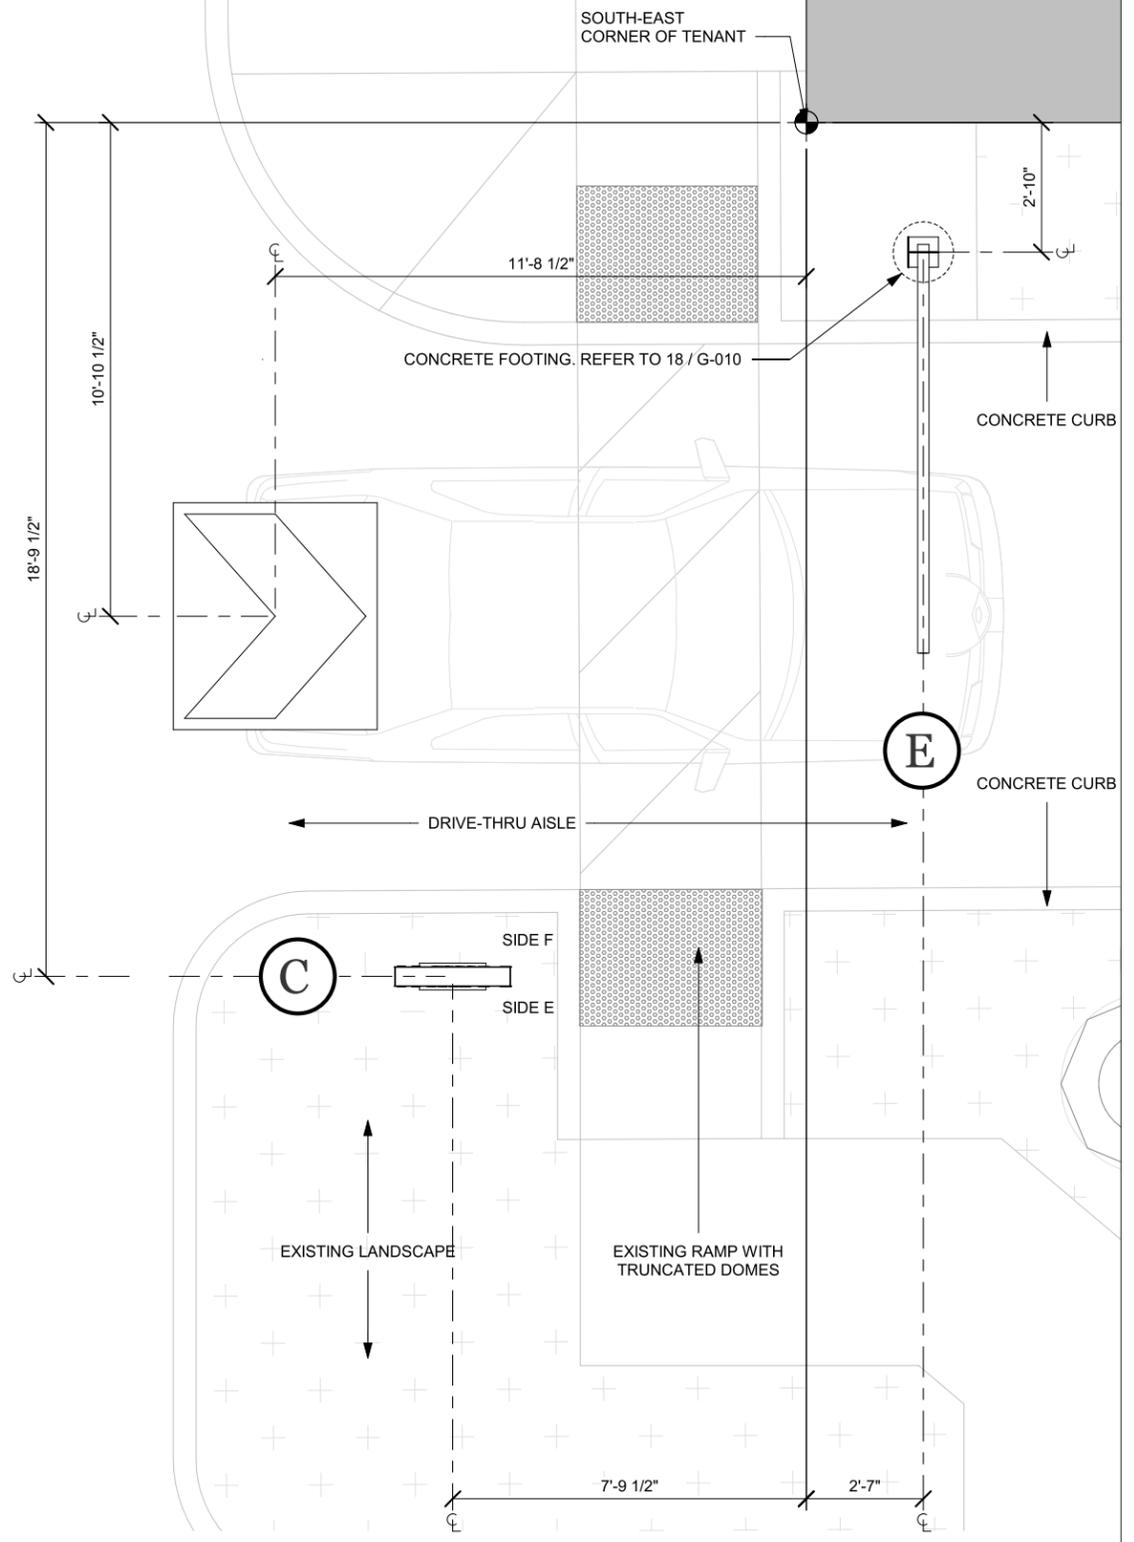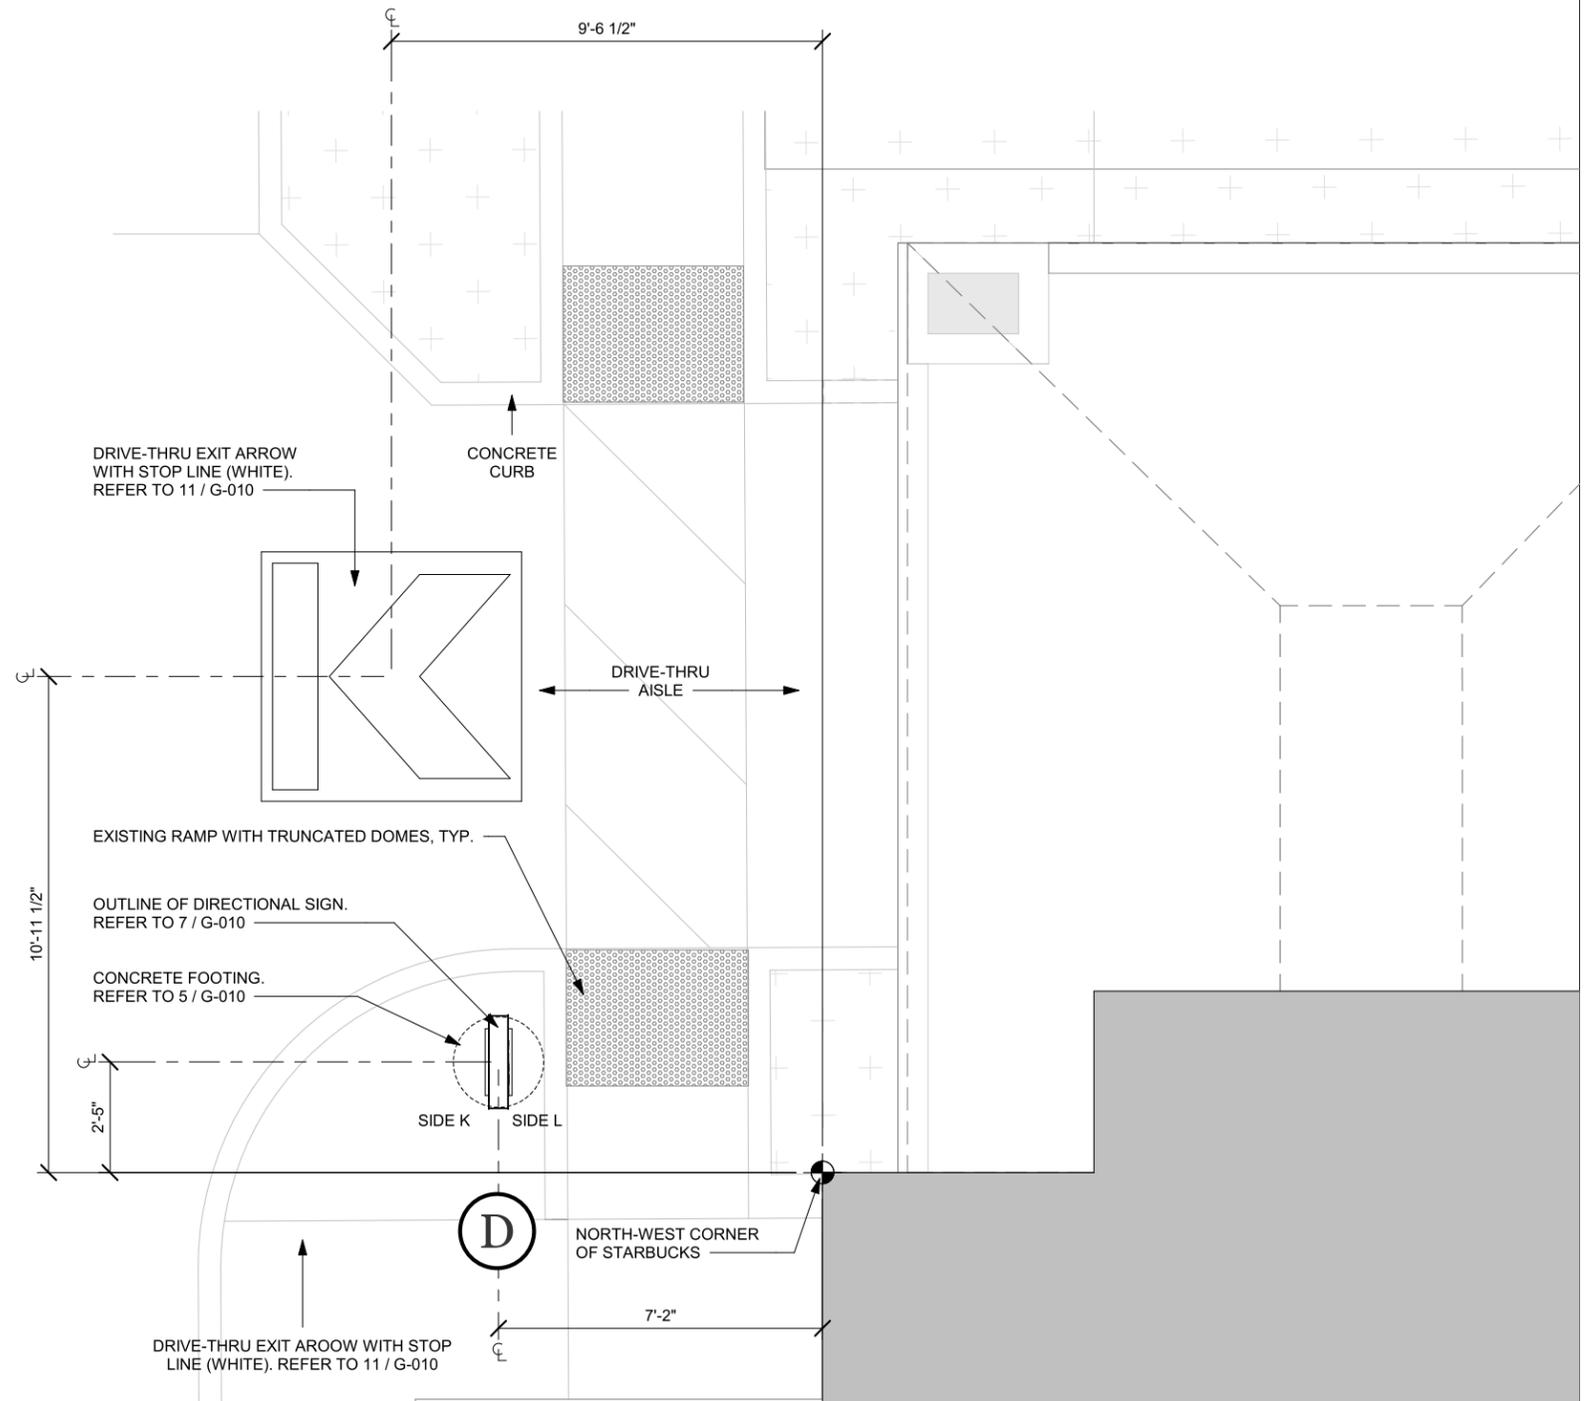

ENLARGED DRIVE PLAN 2

1/4" = 1'-0" SCALE

Los Angeles Division

10235 BELLEGRAVE AVE.
JURUPA VALLEY, CA 91752
TEL: (909) 923-7668
FAX: (909) 923-5015

© 2018 by YESCO LLC
www.yesco.com
All rights reserved.

CLIENT:



6100 WARNER AVE.
HUNTINGTON BEACH, CA 92647

ACCOUNT EXECUTIVE:

JAY RESAR

DESIGN:

TORK

DATE:

10/30/17

REV./DATE/DESIGNER

R2 / TORK / 08/22/18

Separated ground signs into it's own packet

R3 / TORK / 11/02/18

Added additional signs to complete branding book

R4 / TORK / 11/14/18

Revised per city comments

CUSTOMER APPROVAL:

- Accepted w/o changes
- Accepted w/ changes as noted
- Revise as noted & re-submit

SIGNATURE _____ DATE _____

PRODUCTION APPROVAL:

SALES EXECUTIVE _____ DATE _____

PRODUCTION MGR. _____ DATE _____

This drawing was created to assist you in visualizing our proposal. The original ideas herein are the property of YESCO SIGNS, LLC. Permission to copy or revise this drawing can only be obtained through a written agreement with YESCO. See your sales representative or call the nearest office of YESCO.

This sign is intended to be installed in accordance with the requirements of Article 600 of the National Electrical Code and/or other applicable local codes. This includes proper grounding and bonding of the sign.

Colors represented in this drawing are for presentation only. They cannot match actual processes being used on finished products. All salespersons can reference manufacturer's color charts at your request. Cost of providing necessary writing to sign area is not included in this sign proposal.

PROJECT NUMBER:

ART 01632 R4

SHEET:

S06

NORTH ELEVATION

A1 60" Logo Disk Cab.
Sign Area = 19.62

B1 48" DT Cabinet (RH)
Sign Area = 6.96


Total Area = 26.58

WEST ELEVATION

A2 60" Logo Disk Cab.
Sign Area = 19.62


B2 48" DT Cabinet (RH)
Sign Area = 6.96

Total Area = 26.58

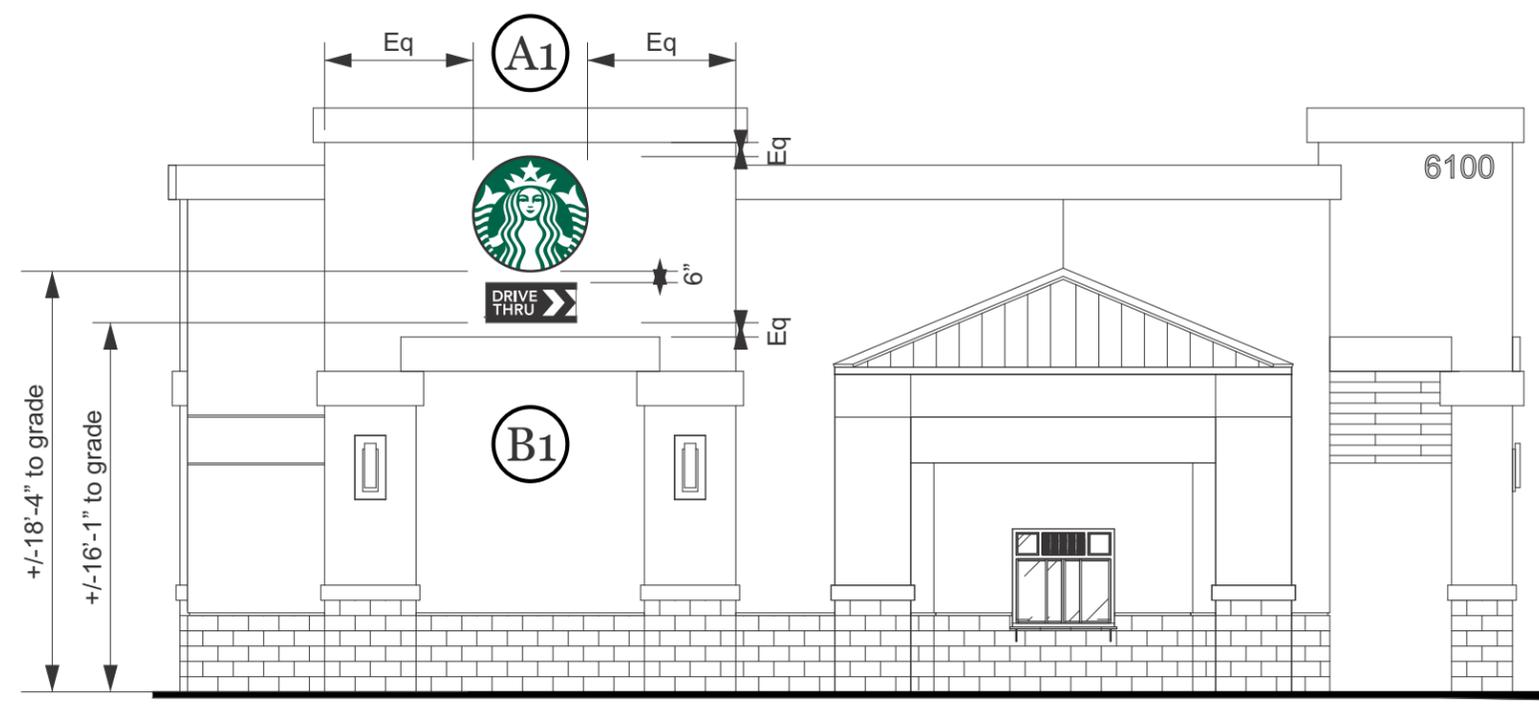

NORTH ELEVATION

1/8" = 1'-0" SCALE

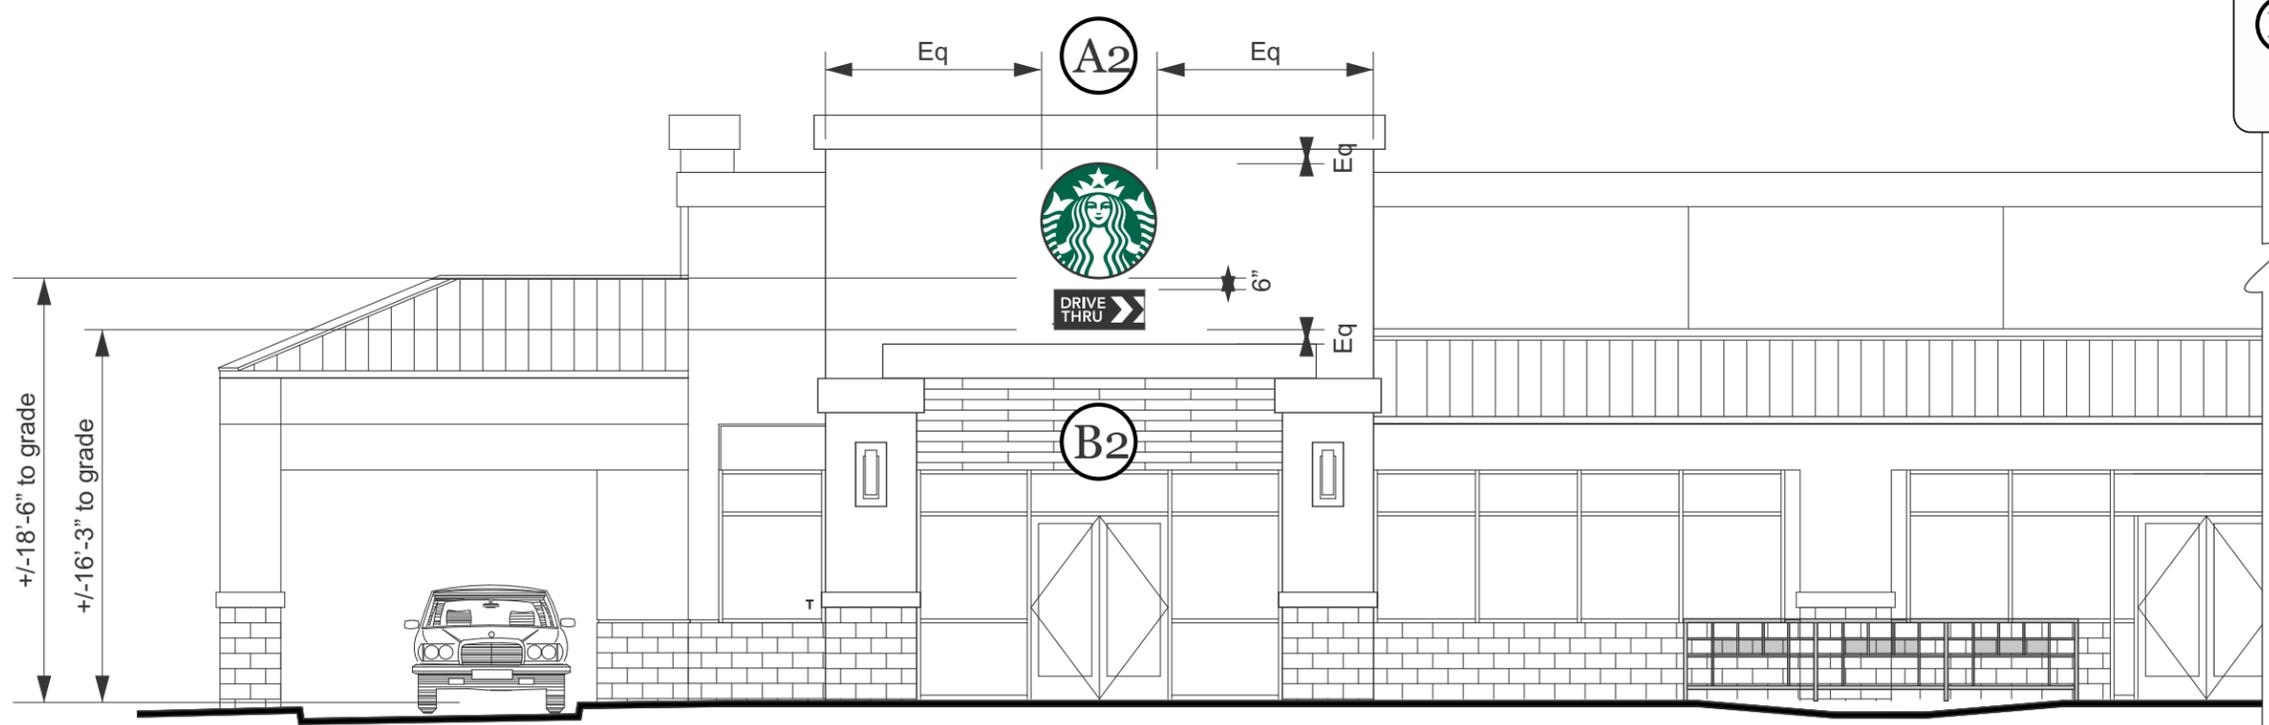

WEST ELEVATION

1/8" = 1'-0" SCALE

Los Angeles Division

10235 BELLEGRAVE AVE.
JURUPA VALLEY, CA 91752
TEL: (909) 923-7668
FAX: (909) 923-5015

© 2018 by YESCO LLC
www.yesco.com
All rights reserved.

CLIENT:



6100 WARNER AVE.
HUNTINGTON BEACH, CA 92647

ACCOUNT EXECUTIVE:

JAY RESAR

DESIGN:

TORK

DATE:

10/30/17

REV./DATE/DESIGNER

R2 / TORK / 08/22/18

Separated ground signs into it's own packet

R3 / TORK / 11/02/18

Added additional signs to complete branding book

R4 / TORK / 11/14/18

Revised per city comments

CUSTOMER APPROVAL:

Accepted w/o changes

Accepted w/ changes as noted

Revise as noted & re-submit

SIGNATURE _____ DATE _____

PRODUCTION APPROVAL:

SALES EXECUTIVE _____ DATE _____

PRODUCTION MGR. _____ DATE _____

This drawing was created to assist you in visualizing our proposal. The original ideas herein are the property of YESCO SIGNS, LLC. Permission to copy or revise this drawing can only be obtained through a written agreement with YESCO. See your sales representative or call the nearest office of YESCO.

This sign is intended to be installed in accordance with the requirements of Article 600 of the National Electrical Code and/or other applicable local codes. This includes proper grounding and bonding of the sign.


Colors represented in this drawing are for presentation only. They cannot match actual processes being used on finished products. All salespersons can reference manufacturer's color charts at your request. Cost of providing necessary wiring to sign area is not included in this sign proposal.

PROJECT NUMBER:


ART 01632 R4

SHEET:

S07

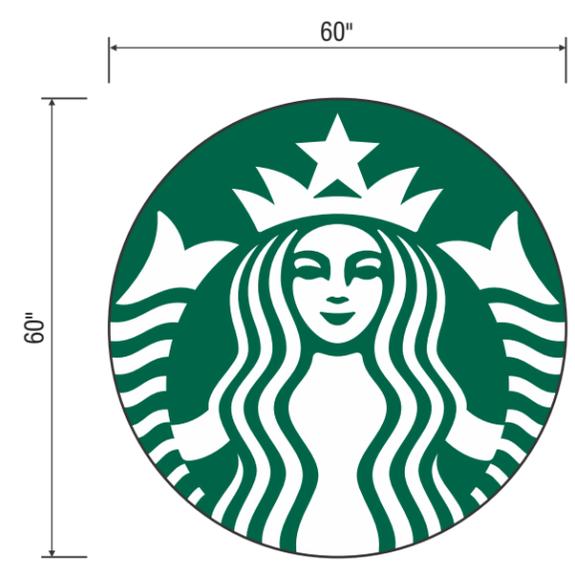

Front View

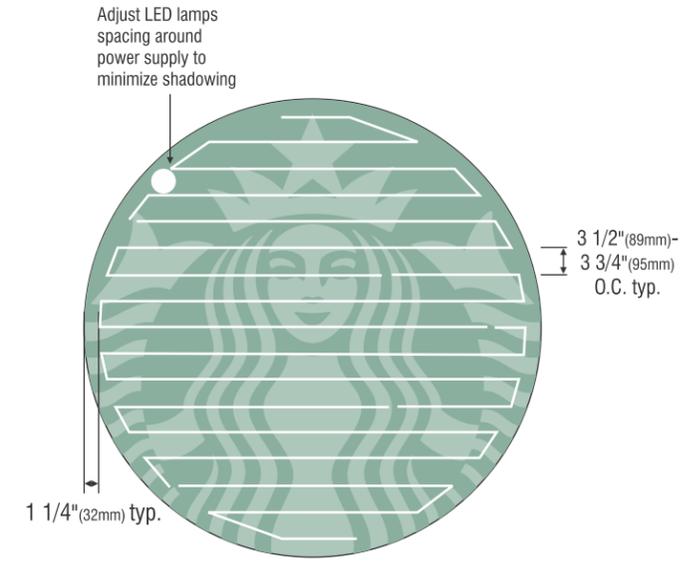

LED Detail



Section View



Side View

A1 A2

60" S/F LOGO DISK CABINETS

QUANTITY: Two (2), Manufacture and Install

Design: 13164

Scale: 1/2" = 1'-0"


SPECIFICATIONS:

60" Single faced internally illuminated wall mount logo disk. Cabinet to be 3"(76mm) deep, fabricated aluminum sidewalls and back. Paint cabinet black polyurethane. Faces to be 3/16"(5mm) Acrylite 015-2GP. 1"(25mm) black trimcap with square head screws retainer edging.

Graphics of logo to be 1st surface 3M Translucent Scotchcal vinyl- Holly Green #3630-76. Siren to show thru White.

Internally illuminate logo disk with white LED's installed to back of disk. Power with self-contained power supply contained with an U.L. enclosure covered in white vinyl film. Fasten to wall with required fasteners.

Sign must be approved by the National Electrical Code, Underwriters Laboratory, CUL, and all applicable local codes. Disconnect switch in primary to be within sight of sign (sign includes power supply enclosure) REF: NEC 110-3[B] 600-2, 600-4. Primary electrical source 1/2"(13mm) conduit minimum) REF: NEC 600-6, 600-21 (provided by installer).

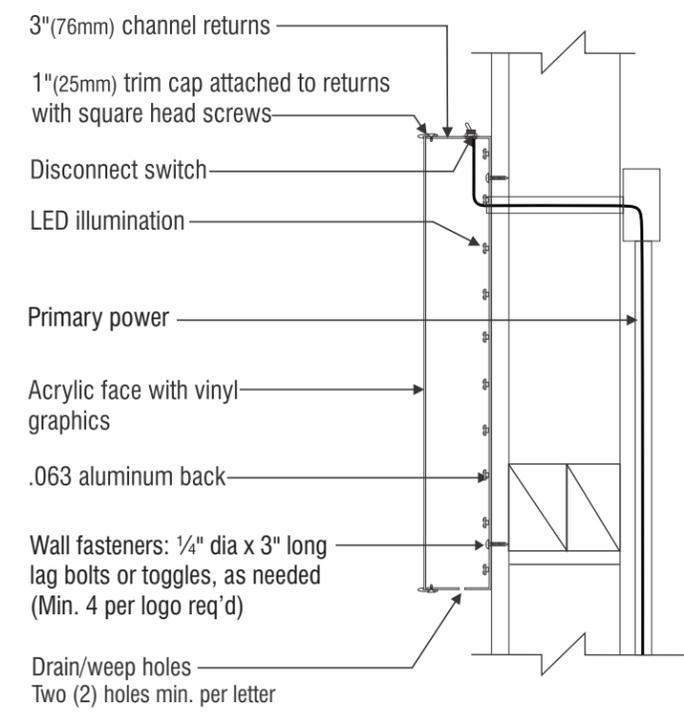

Disk Section View Typ.

NTS



Note: Red dotted line denotes sign area calculation



Disk 60in S/F Illuminated wall mount EVOLVED			
Size	Sq.Ft.	Sq.M.	Volts
60" (1524mm)	19.62	1.82	120

Los Angeles Division

10235 BELLEGRAVE AVE.
JURUPA VALLEY, CA 91752
TEL: (909) 923-7668
FAX: (909) 923-5015

© 2018 by YESCO LLC
www.yesco.com
All rights reserved.

CLIENT:



6100 WARNER AVE.
HUNTINGTON BEACH, CA 92647

ACCOUNT EXECUTIVE:

JAY RESAR

DESIGN:

TORK

DATE:

10/30/17

REV./DATE/DESIGNER

R2 / TORK / 08/22/18

Separated ground signs into it's own packet

R3 / TORK / 11/02/18

Added additional signs to complete branding book

R4 / TORK / 11/14/18

Revised per city comments

CUSTOMER APPROVAL:

Accepted w/o changes

Accepted w/ changes as noted

Revise as noted & re-submit

SIGNATURE _____ DATE _____

PRODUCTION APPROVAL:

SALES EXECUTIVE _____ DATE _____

PRODUCTION MGR. _____ DATE _____

This drawing was created to assist you in visualizing our proposal. The original ideas herein are the property of YESCO SIGNS, LLC. Permission to copy or revise this drawing can only be obtained through a written agreement with YESCO. See your sales representative or call the nearest office of YESCO.

This sign is intended to be installed in accordance with the requirements of Article 600 of the National Electrical Code and/or other applicable local codes. This includes proper grounding and bonding of the sign.

Colors represented in this drawing are for presentation only. They cannot match actual processes being used on finished products. All salespersons can reference manufacturer's color charts at your request. Cost of providing necessary wiring to sign area is not included in this sign proposal.

PROJECT NUMBER:

ART 01632 R4

SHEET:

S08

Sign Specifications:

Cabinet:

- Fabricated .090" [2mm] aluminum housing painted black to match RAL 7021M with white end caps as shown.
- Back to be .125" [3mm] aluminum.
- Directional copy and chevrons backed up with .125" [3mm] #7328 white polycarbonate. All polycarbonate face elements to be attached to aluminum face panel with weld studs.
- Interior aluminum surfaces of sign cabinet to be painted white with Lacryl Starbrite.
- Welded aluminum construction with no visible fasteners. Fasteners retaining the hinged face will be located on the bottom such that they are not visible. All fasteners used in the assembly of internal components shall be coated to prevent corrosion.
- Internal structure of cabinet shall be per approved shop drawings.
- Graphic elements are internally illuminated using LED system or Starbucks approved equal. LED's to be mounted on back panel with self-contained power supply. All electrical components are removable for service.

Regulatory:

- Sign must meet all regulations in the National Electric Code as well as any local or state electrical codes.
- As per NEC 600.6, sign is equipped with a service disconnect switch.
- Sign must be listed as an Electric Sign per Underwriters Laboratories UL48 and/or CSA and bear the appropriate UL, CUL or CSA relevant certification marks.
- Primary power by electrical contractor per NEC.




These Drawings and Specifications are confidential and shall remain the sole property of Starbucks Corporation, which is the owner of the copyright in this work. They shall not be reproduced (in whole or in part), shared with third parties or used in any manner on other projects or extensions to this project without the prior written consent of Starbucks Corporation.

This drawing is a Design Development Document. Site specific modifications made under the responsible charge of the Architect and/or Engineer-of-Record will be required prior to using this document for Bidding, Permitting, or Construction.

Size	Sq. Ft. ¹	Sq. Ft. ²	Volts	Amps
21" (533mm)	4.52	6.96	120	0.85


1: Figured as illuminated center part
2: Figured as complete signage

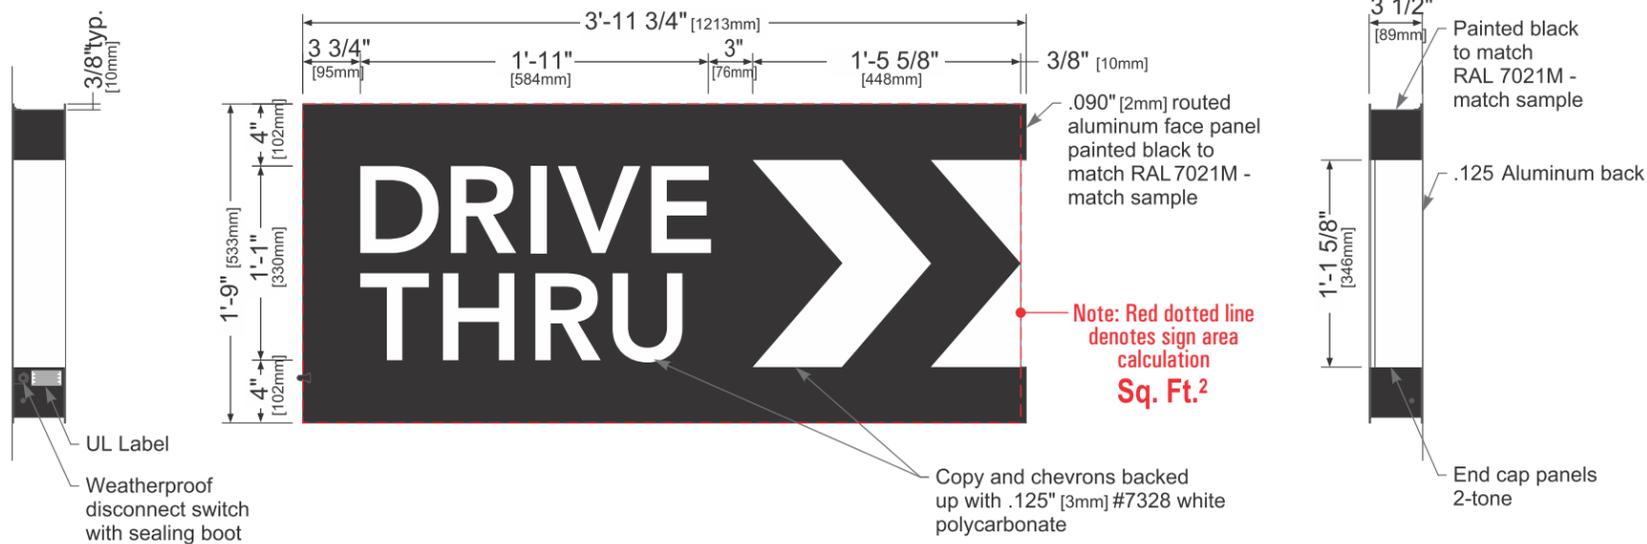

Left Side View


Front Elevation View

 Right Side View




48" S/F DRIVE THRU WALL CABINET (RH)
QUANTITY: Two (2) Logo Cabinets, Manufacture and Install


Design: 14099
Scale: 1" = 1'-0"

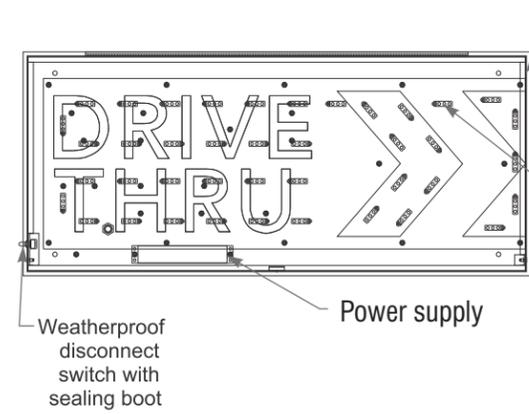

Vertical Cross-Section View, Typ.

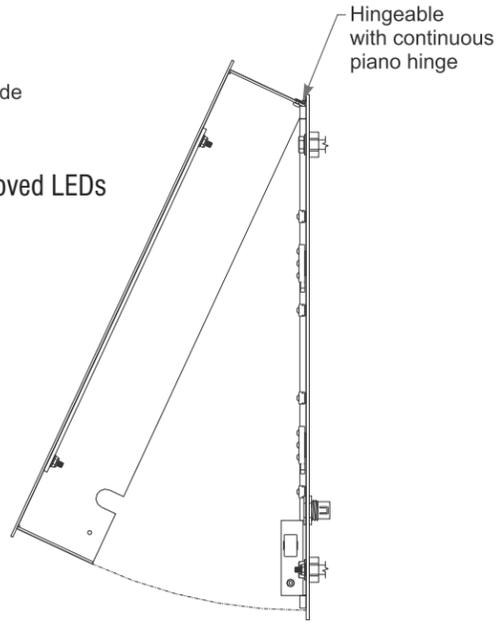

Service Position View

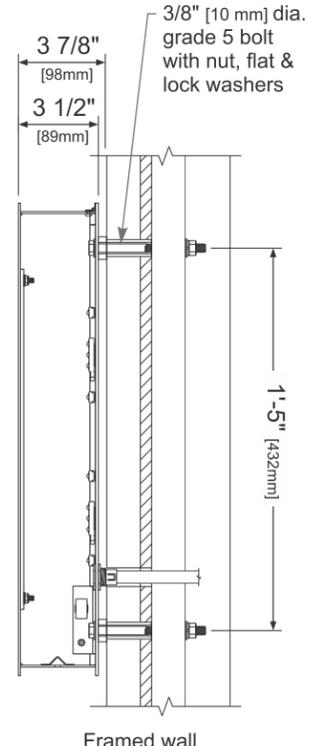

Section View at Installation Detail

Los Angeles Division

10235 BELLEGRAVE AVE.
JURUPA VALLEY, CA 91752
TEL: (909) 923-7668
FAX: (909) 923-5015

© 2018 by YESCO LLC
www.yesco.com
All rights reserved.

CLIENT:



6100 WARNER AVE.
HUNTINGTON BEACH, CA 92647

ACCOUNT EXECUTIVE:

JAY RESAR

DESIGN:

TORK

DATE:

10/30/17

REV./DATE/DESIGNER

R2 / TORK / 08/22/18
Separated ground signs into it's own packet
R3 / TORK / 11/02/18
Added additional signs to complete branding book
R4 / TORK / 11/14/18
Revised per city comments

CUSTOMER APPROVAL:

- Accepted w/o changes
- Accepted w/ changes as noted
- Revise as noted & re-submit

SIGNATURE _____ DATE _____

PRODUCTION APPROVAL:

SALES EXECUTIVE _____ DATE _____

PRODUCTION MGR. _____ DATE _____

This drawing was created to assist you in visualizing our proposal. The original ideas herein are the property of YESCO SIGNS, LLC. Permission to copy or revise this drawing can only be obtained through a written agreement with YESCO. See your sales representative or call the nearest office of YESCO.

This sign is intended to be installed in accordance with the requirements of Article 600 of the National Electrical Code and/or other applicable local codes. This includes proper grounding and bonding of the sign.

Colors represented in this drawing are for presentation only. They cannot match actual processes being used on finished products. All salespersons can reference manufacturer's color charts at your request. Cost of providing necessary wiring to sign area is not included in this sign proposal.

PROJECT NUMBER:

ART 01632 R4

SHEET:

S09

Sign Specifications:

Cabinet:

- Fabricated .090" [2mm] aluminum housing painted black to match RAL 7021M with white end caps as shown.
- Directional copy and chevrons backed up with .125" [3mm] #7328 white polycarbonate.
- 3/8" [10mm] clear polycarbonate routed to push thru aluminum face.
- All polycarbonate face elements to be attached to aluminum face panel with weld studs.
- Interior aluminum surfaces of sign cabinet to be painted white with Lacryl Starbrite.
- Welded aluminum construction with no visible fasteners. Fasteners retaining the hinged face will be located on the bottom such that they are not visible. All fasteners used in the assembly of internal components shall be coated to prevent corrosion.
- Internal structure of cabinet shall be per approved shop drawings.
- Graphic elements are internally illuminated using GE Tetra MiniMax LED system or Starbucks approved equal. LED's to be mounted on an internal baffle with self-contained power supply. All electrical components are removable for service.

Support:

- Supporting structure will be all welded aluminum tube and channel construction painted black to match RAL 7021M as per approved shop drawings and shall be integral to the sign cabinet.
- Base tube will be constructed so that it can be retro-fittable to existing sign foundations. All foundations, existing and new must be analyzed for suitability and must meet all local city or state codes regulations.

Regulatory:


- Sign must meet all regulations in the National Electric Code as well as any local or state electrical codes.
- As per NEC 600.6, sign is equipped with a service disconnect switch.
- Sign must be listed as an Electric Sign per Underwriters Laboratories UL48 and/or CSA and bear the appropriate UL, CUL or CSA relevant certification marks.
- Primary power by electrical contractor per NEC.



These Drawings and Specifications are confidential and shall remain the sole property of Starbucks Corporation, which is the owner of the copyright in this work. They shall not be reproduced (in whole or in part), shared with third parties or used in any manner on other projects or extensions to this project without the prior written consent of Starbucks Corporation.

This drawing is a Design Development Document. Site specific modifications made under the responsible charge of the Architect and/or Engineer-of-Record will be required prior to using this document for Bidding, Permitting, or Construction.

Size	Sq. Ft.	Volts	Amps
46"	1.11	120	0.85

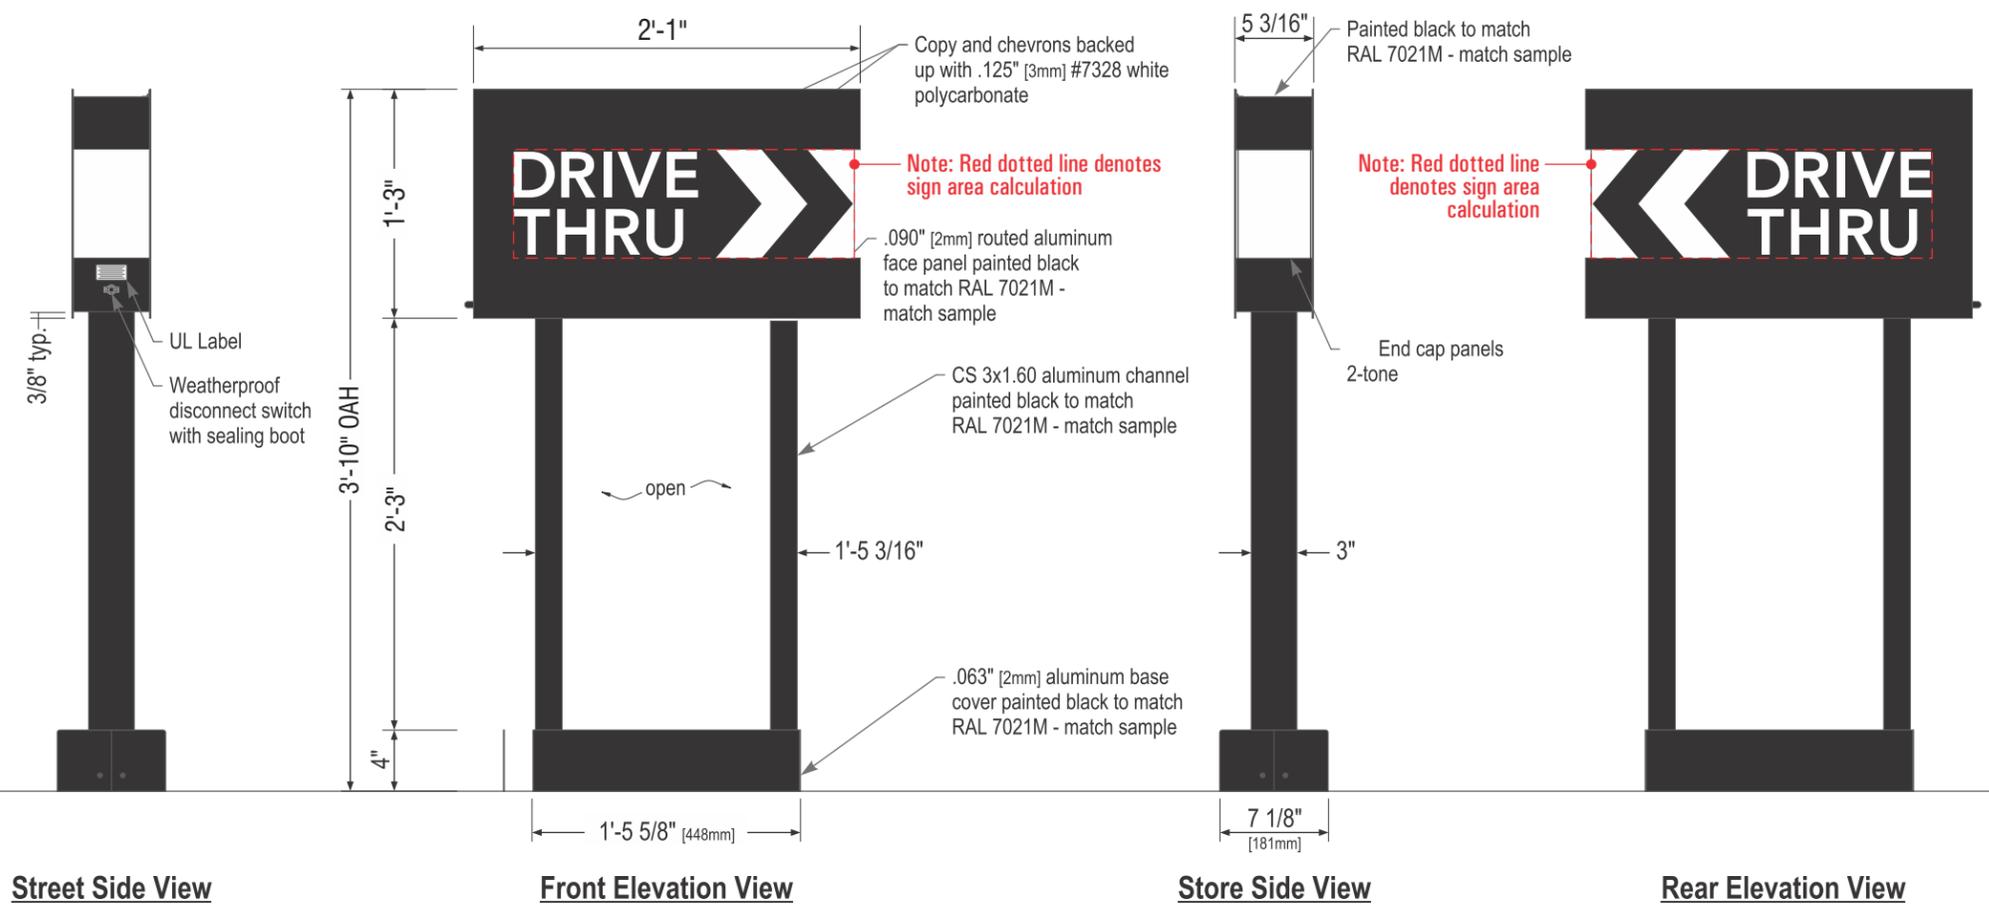


46" D/F DRIVE THRU DIRECTIONAL SIGN - W/ NO LOGO


QUANTITY: One (1) - Manufacture and Install

Design: 14104/Custom

Scale: 1" = 1'-0"

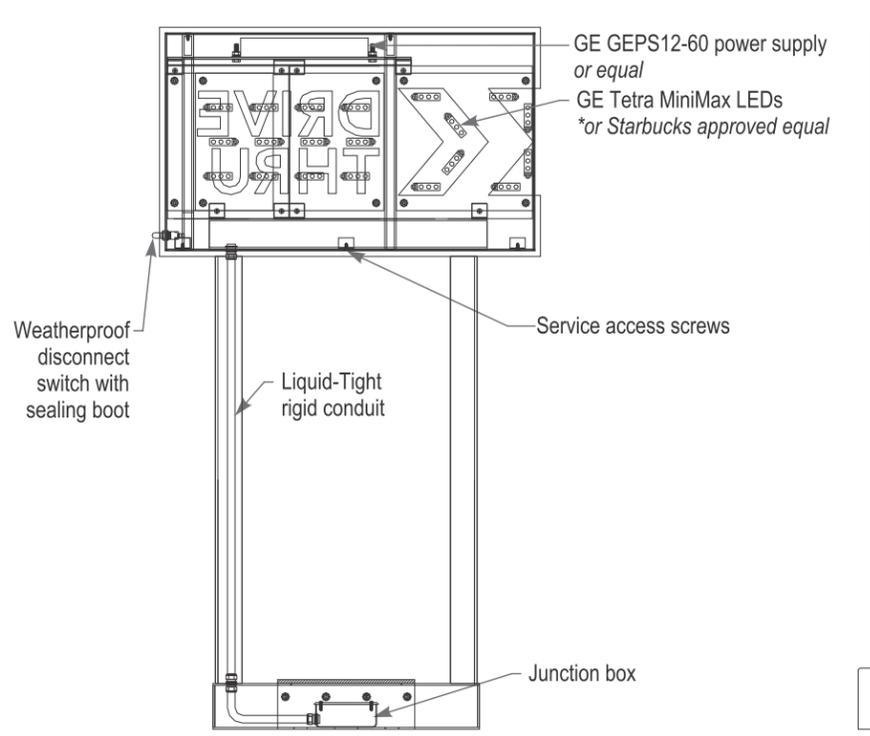

Vertical Cross-Section View, Typ.

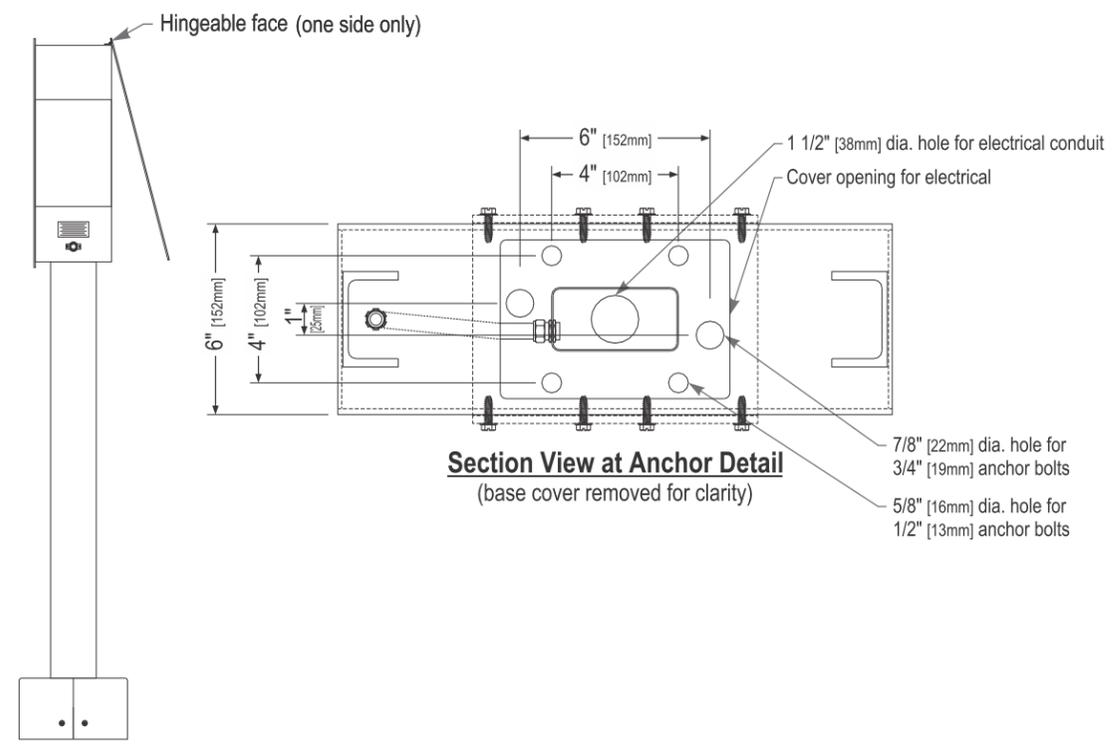

Service Position View

Section View at Anchor Detail
(base cover removed for clarity)

Los Angeles Division

10235 BELLEGRAVE AVE.
JURUPA VALLEY, CA 91752
TEL: (909) 923-7668
FAX: (909) 923-5015

© 2018 by YESCO LLC
www.yesco.com
All rights reserved.

CLIENT:



6100 WARNER AVE.
HUNTINGTON BEACH, CA 92647

ACCOUNT EXECUTIVE:

JAY RESAR

DESIGN:

TORK

DATE:

10/30/17

REV./DATE/DESIGNER

R2 / TORK / 08/22/18
Separated ground signs into it's own packet
R3 / TORK / 11/02/18
Added additional signs to complete branding book
R4 / TORK / 11/14/18
Revised per city comments

CUSTOMER APPROVAL:

- Accepted w/o changes
- Accepted w/ changes as noted
- Revise as noted & re-submit

SIGNATURE _____ DATE _____

PRODUCTION APPROVAL:

SALES EXECUTIVE _____ DATE _____

PRODUCTION MGR. _____ DATE _____

This drawing was created to assist you in visualizing our proposal. The original ideas herein are the property of YESCO SIGNS, LLC. Permission to copy or revise this drawing can only be obtained through a written agreement with YESCO. See your sales representative or call the nearest office of YESCO.

This sign is intended to be installed in accordance with the requirements of Article 600 of the National Electrical Code and/or other applicable local codes. This includes proper grounding and bonding of the sign.

Colors represented in this drawing are for presentation only. They cannot match actual processes being used on finished products. All salespersons can reference manufacturer's color charts at your request. Cost of providing necessary wiring to sign area is not included in this sign proposal.

PROJECT NUMBER:

ART 01632 R4

SHEET:

S10

Sign Specifications:

Cabinet:

- Fabricated .090" [2mm] aluminum housing painted black to match RAL 7021M with white end caps as shown.
- Directional copy backed up with .125" [3mm] #7328 white polycarbonate. All polycarbonate face elements to be attached to aluminum face panel with weld studs.
- Interior aluminum surfaces of sign cabinet to be painted white with Lacryl Starbrite.
- Welded aluminum construction with no visible fasteners. Fasteners retaining the hinged face will be located on the bottom such that they are not visible. All fasteners used in the assembly of internal components shall be coated to prevent corrosion.
- Internal structure of cabinet shall be per approved shop drawings.
- Graphic elements are internally illuminated using LED system or Starbucks approved equal. LED's to be mounted on an internal baffle with self-contained power supply. All electrical components are removable for service.

Support:

- Supporting structure will be all welded aluminum tube and channel construction painted black to match RAL 7021M as per approved shop drawings and shall be integral to the sign cabinet.
- Base tube will be constructed so that it can be retro-fittable to existing sign foundations. All foundations, existing and new must be analyzed for suitability and must meet all local city or state codes regulations.

Regulatory:


- Sign must meet all regulations in the National Electric Code as well as any local or state electrical codes.
- As per NEC 600.6, sign is equipped with a service disconnect switch.
- Sign must be listed as an Electric Sign per Underwriters Laboratories UL48 and/or CSA and bear the appropriate UL, CUL or CSA relevant certification marks.
- Primary power by electrical contractor per NEC.





These Drawings and Specifications are confidential and shall remain the sole property of Starbucks Corporation, which is the owner of the copyright in this work. They shall not be reproduced (in whole or in part), shared with third parties or used in any manner on other projects or extensions to this project without the prior written consent of Starbucks Corporation.

This drawing is a Design Development Document. Site specific modifications made under the responsible charge of the Architect and/or Engineer-of-Record will be required prior to using this document for Bidding, Permitting, or Construction.

Size	Sq. Ft. 1	Sq. Ft. 2	Volts	Amps
46"	0.72	1.00	120	0.85

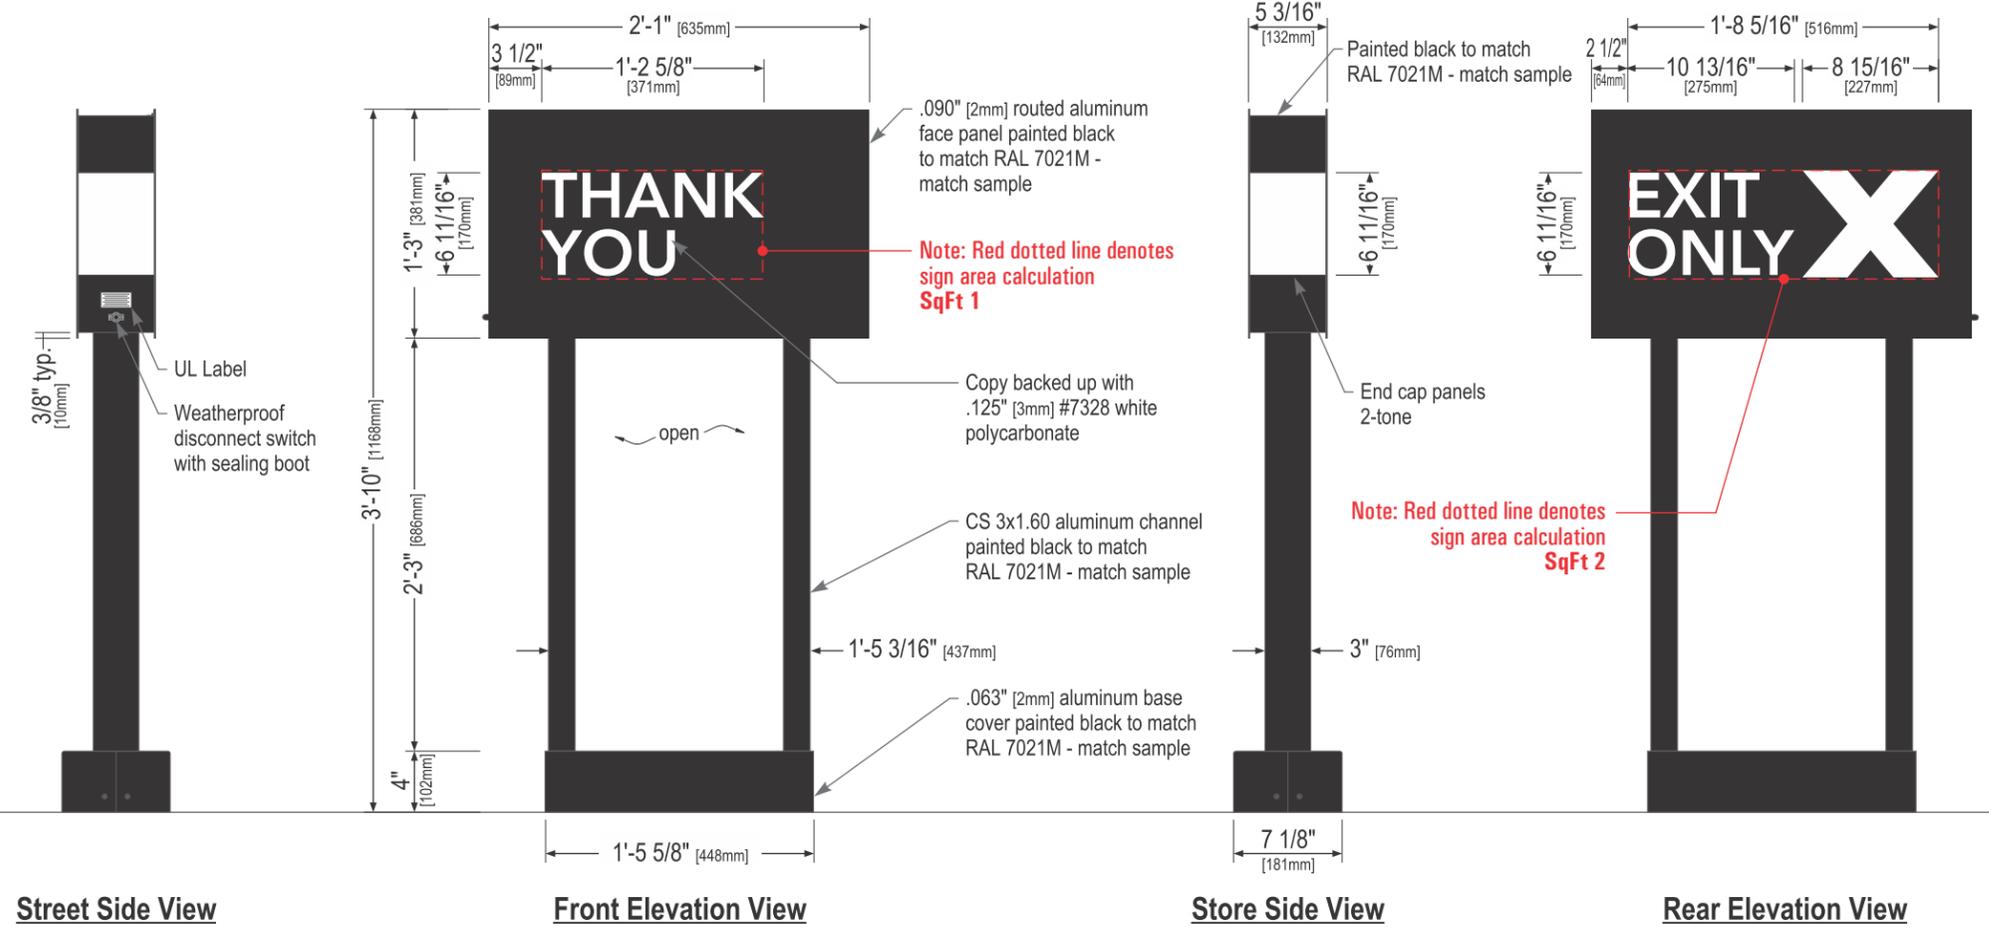



D 46" D/F THANK YOU / EXIT ONLY DIRECTIONAL SIGN Design: 14091
 QUANTITY: One (1) - Manufacture & Install Scale: 1" = 1'-0"

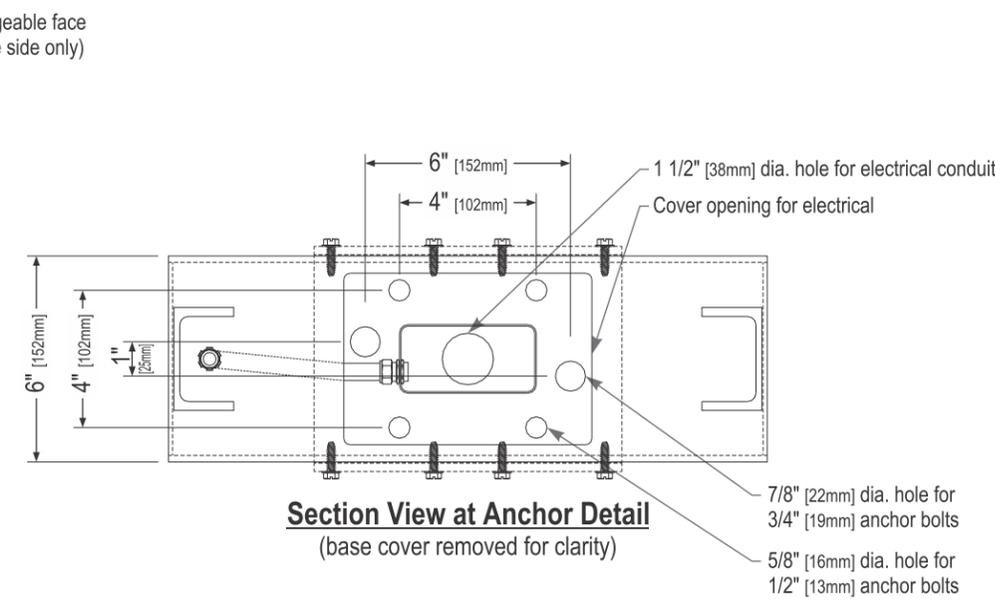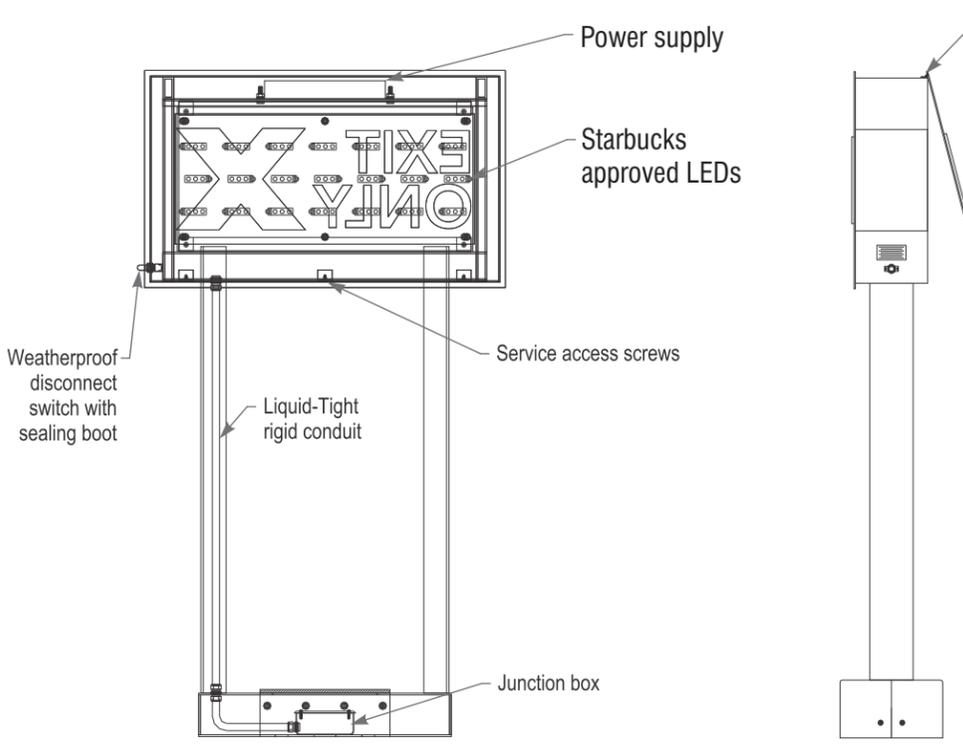

Vertical Cross-Section View, Typ.

Service Position View

Section View at Anchor Detail (base cover removed for clarity)

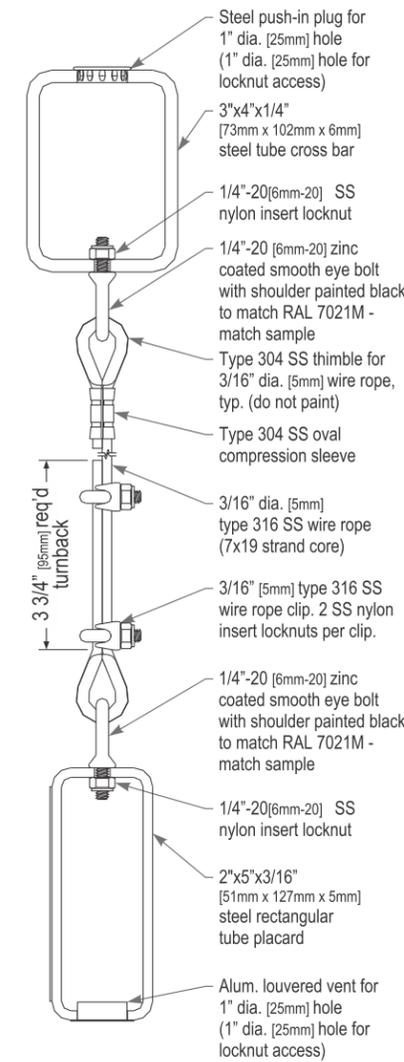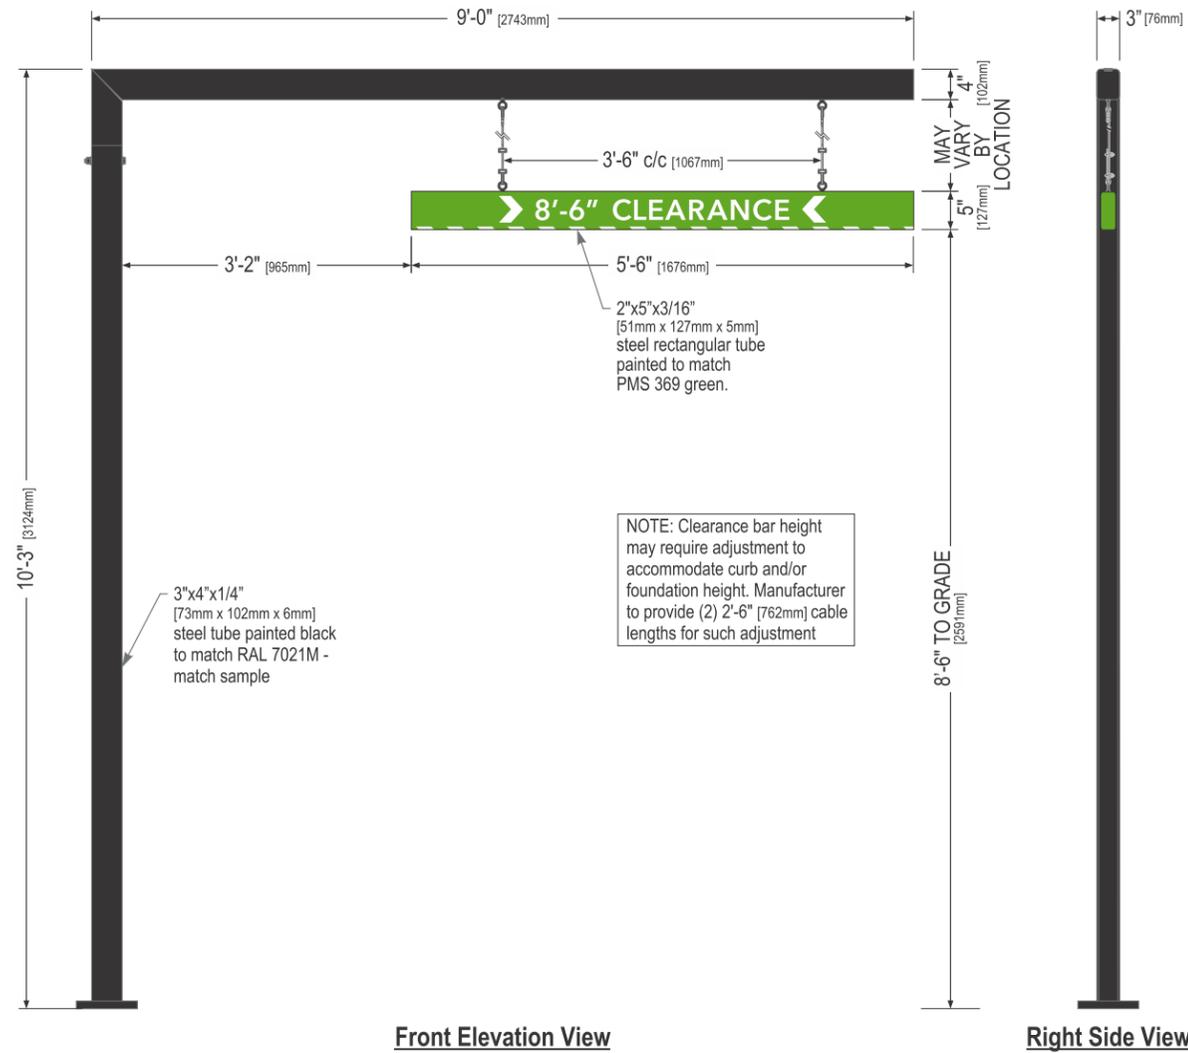

Sign Specifications:

Scraper Bar:

- 2"x5" [51mm x 127mm] steel tube painted to match PMS 369 green.
- Flush steel end caps painted to match PMS 369 green.
- Copy and chevrons to be 1st surface computer cut 3M #680-10 white Scotchlite reflective vinyl film.
- Bottom striping to be 1st surface computer cut 3M #680-10 white Scotchlite reflective vinyl film. Striping extends 3/8" [10mm] onto front face.
- Suspend from support with SS cable & hardware. Cable provided requires field adjustment for proper clearance height.




Support:

- Supporting structure will be all welded steel tube construction painted black to match RAL 7021M as per approved shop drawings.
- Base tube will be constructed so that it can be retro-fittable to existing sign foundations. All foundations, existing and new must be analyzed for suitability and must meet all local city or state codes regulations.

These Drawings and Specifications are confidential and shall remain the sole property of Starbucks Corporation, which is the owner of the copyright in this work. They shall not be reproduced (in whole or in part), shared with third parties or used in any manner on other projects or extensions to this project without the prior written consent of Starbucks Corporation.

This drawing is a Design Development Document. Site specific modifications made under the responsible charge of the Architect and/or Engineer-of-Record will be required prior to using this document for Bidding, Permitting, or Construction.

Size	Sq. Ft.
10'-3" (3124mm)	2.29

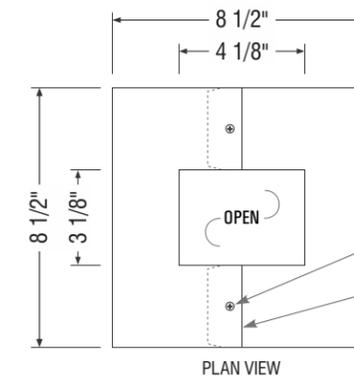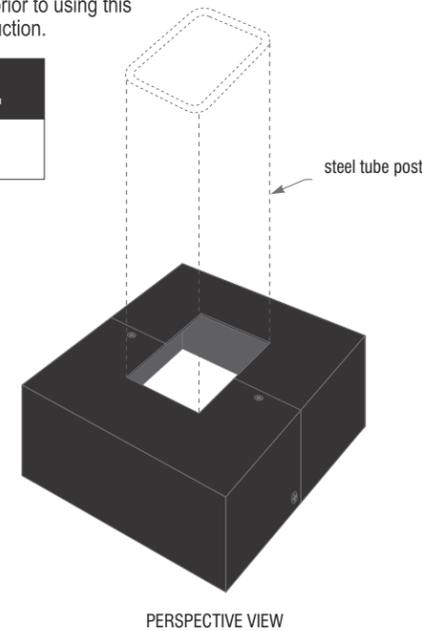
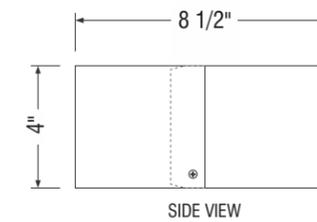


Base Plate Cover Detail

Scale: 1" = 6"

E NEW DT CLEARANCE BAR ARROW SERIES FREESTANDING
 QUANTITY: One(1) Clearance Bar - Manufacture & Install

Design: 14106
 Scale: 1/2" = 1'-0"

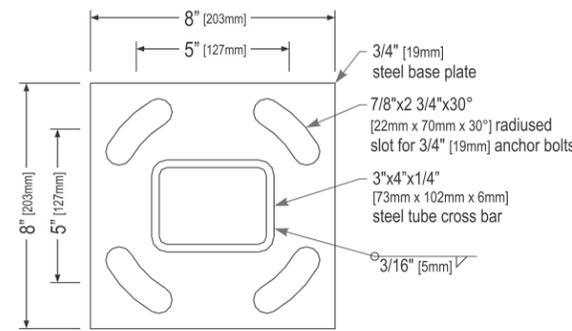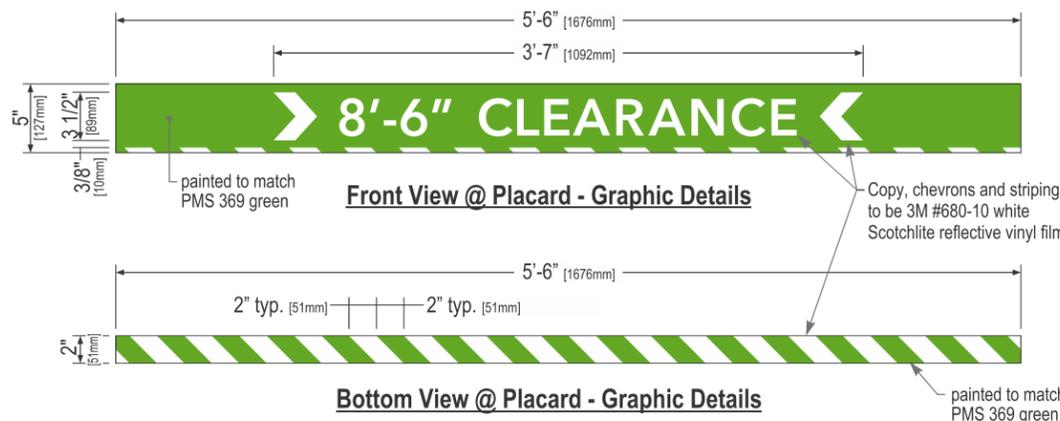

Base Plate Detail
 Scale: 1" = 6"

Los Angeles Division

10235 BELLEGRAVE AVE.
 JURUPA VALLEY, CA 91752
 TEL: (909) 923-7668
 FAX: (909) 923-5015

© 2018 by YESCO LLC
 www.yesco.com
 All rights reserved.

CLIENT:



6100 WARNER AVE.
 HUNTINGTON BEACH, CA 92647

ACCOUNT EXECUTIVE:

JAY RESAR

DESIGN:

TORK

DATE:

10/30/17

REV./DATE/DESIGNER

- R2 / TORK / 08/22/18
- Separated ground signs into it's own packet
- R3 / TORK / 11/02/18
- Added additional signs to complete branding book
- R4 / TORK / 11/14/18
- Revised per city comments

CUSTOMER APPROVAL:

- Accepted w/o changes
- Accepted w/ changes as noted
- Revise as noted & re-submit

SIGNATURE _____ DATE _____

PRODUCTION APPROVAL:

SALES EXECUTIVE _____ DATE _____

PRODUCTION MGR. _____ DATE _____

This drawing was created to assist you in visualizing our proposal. The original ideas herein are the property of YESCO SIGNS, LLC. Permission to copy or revise this drawing can only be obtained through a written agreement with YESCO. See your sales representative or call the nearest office of YESCO.

This sign is intended to be installed in accordance with the requirements of Article 600 of the National Electrical Code and/or other applicable local codes. This includes proper grounding and bonding of the sign.


Colors represented in this drawing are for presentation only. They cannot match actual processes being used on finished products. All salespersons can reference manufacturer's color charts at your request. Cost of providing necessary writing to sign area is not included in this sign proposal.

PROJECT NUMBER:

ART 01632 R4

SHEET:

S11

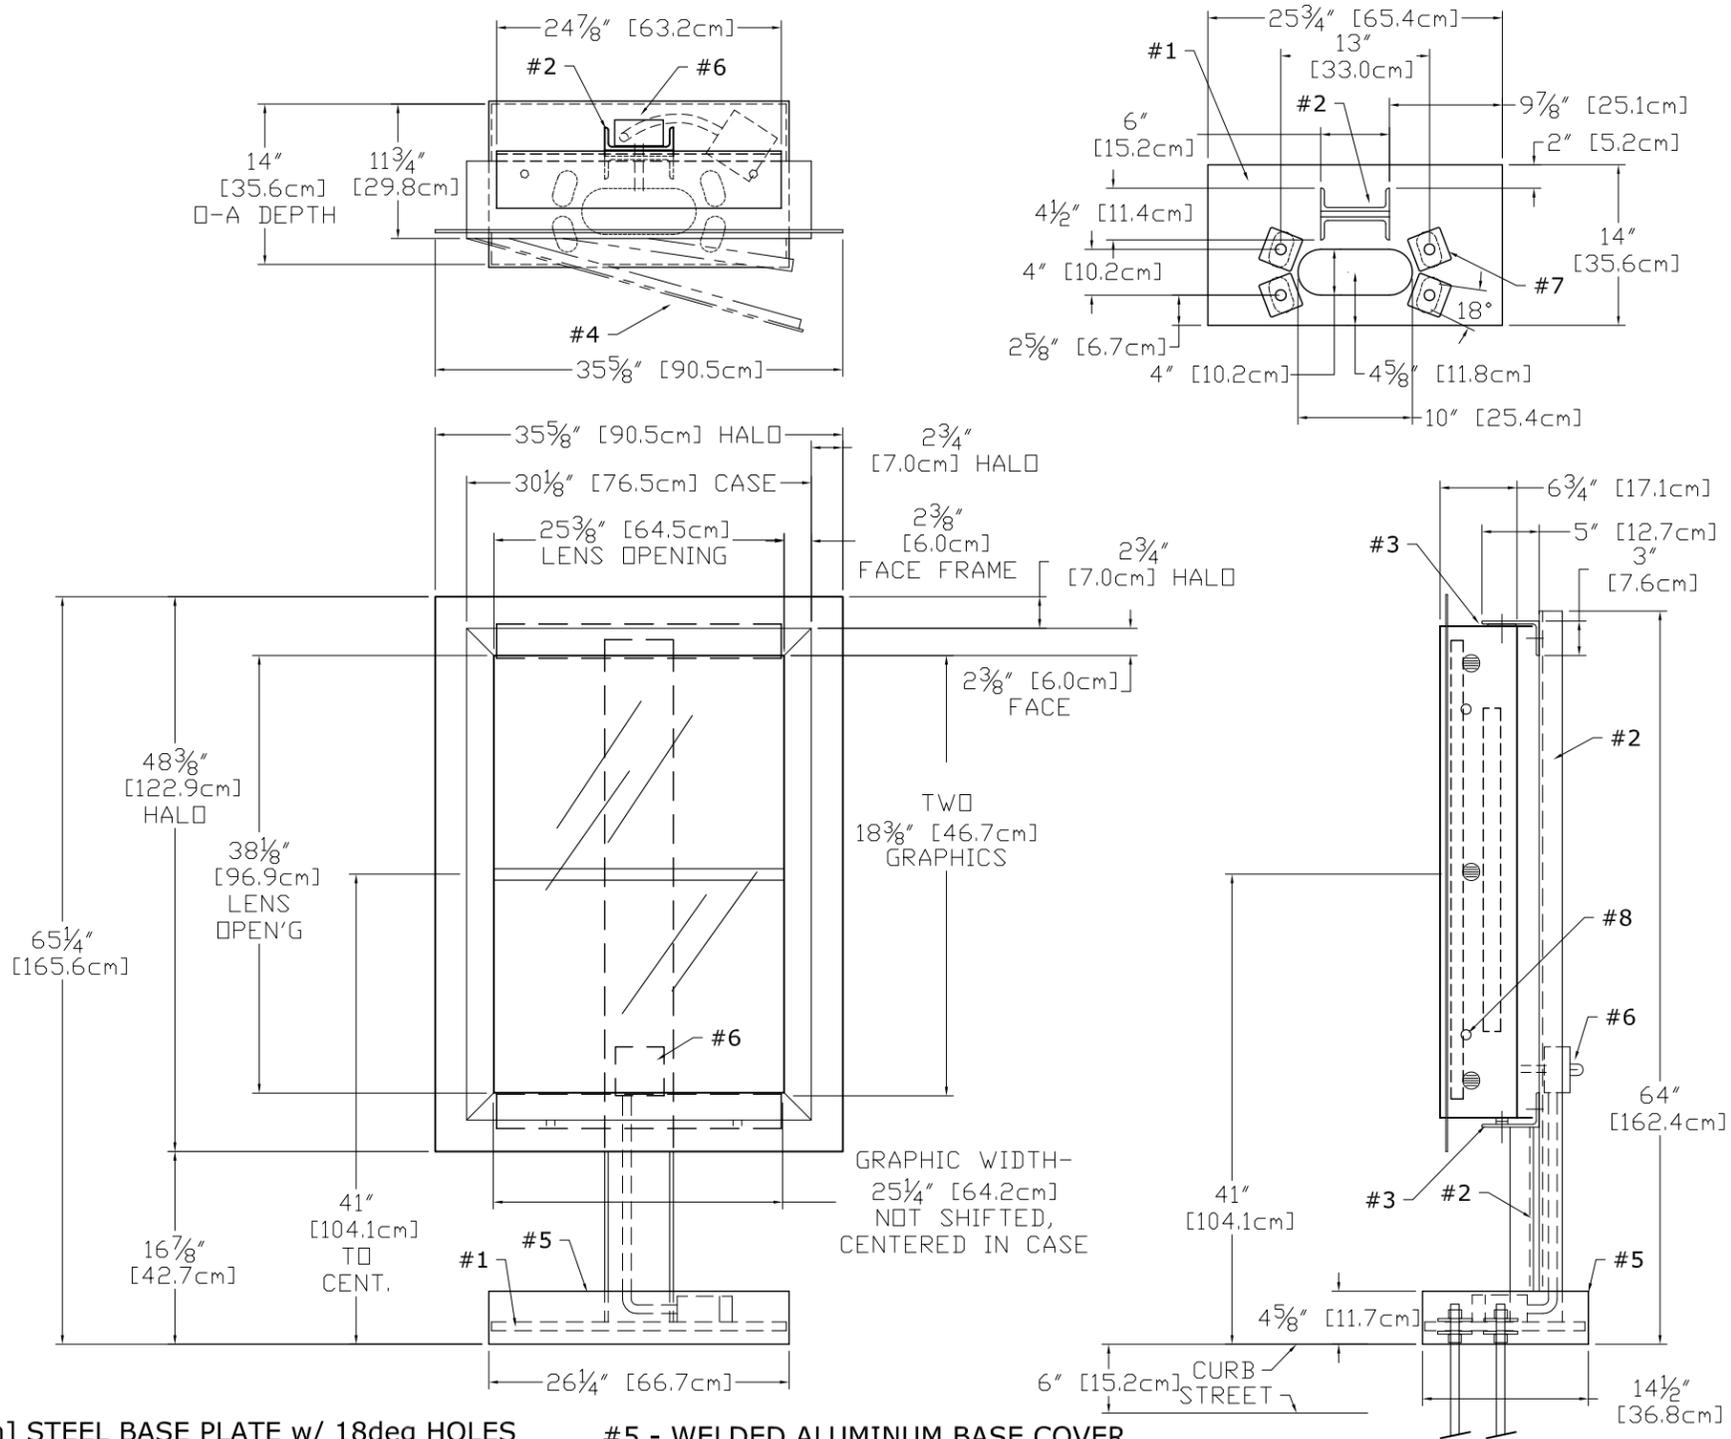

- #1 - 3/4" [19mm] STEEL BASE PLATE w/ 18deg HOLES PATTERN LEFT SQUARE / SYMETRICAL
- #2 - C6X10.5 (6"x2"x5/16") STEEL POST (1x)
- #3 - 5"x3"x1/4" STEEL SUPPORT ANGLES (2x) (WELDED TO STEEL POST)
- #4 - EXTRUDED ALUMINUM MENU BOARD (1x) ONE SPLIT PANEL LIGHTBOX TWO 25 1/4"x18 3/8" GRAPHICS GRAPHIC ASSEMBLY CENTERED, NOT SHIFTED STANDARD LED TUBE LIGHTING, SIDE LOCKS

- #5 - WELDED ALUMINUM BASE COVER
- #6 - WATER-TIGHT BOX w/SWITCHES & SENSOR, RIDGID CONDUIT RUN TO SECOND EXT BOX BELOW BASE COVER, 120 WATT, 0.30Aac
- #7 - 8 BASE WASHERS, 1/4" THICK
- #8 - TWO SIDE MOUNT LOCKS, RETAIN EXISTING KEY #E3-26-819-15

RAL7021 BLACK GREY, 10% SHEEN, EXT

DT PRE ORDER FREESTANDING	14120	11036584
<small>ALL DESIGN, OPERATIVE AND PROCESS DATA PERTAINING TO THE ARTICLE SHOWN ON THIS SHEET IS THE PROPERTY OF DSA PHOTOTECH. IT IS DISCLOSED IN CONFIDENCE AND IS NOT TO BE COPIED, REPRODUCED, REVEALED TO, OR APPROPRIATED BY OTHERS, IN PART OR IN WHOLE, WITHOUT THE EXPRESS CONSENT OF DSA PHOTOTECH. THIS PRINT IS LOANED AND MUST NOT BE USED IN ANY MANNER DETRIMENTAL TO THE INTEREST OF DSA PHOTOTECH.</small>		
		DSA/PHOTOTECH 16961 Central Avenue, Carson, CA 90746 (310) 537-5000 (310) 537-7060 Fax phubbell@dsaphototech.com
DRIVE THRU PRE ORDER w/ STAND		
PAH	DATE 02/06/14	CQSBEDTPRELED
APPROVED 02/06/14		SCALE 1 : 20 SHT 1 OF 1

F NEW PRE-MENU FREESTANDING SIGN
 QUANTITY: One (1) - Install Only. Manufactured by DSA Phototech.

Design: 14120
 Scale: 3/4" = 1'-0"



CALIFORNIA CONTRACTOR LICENSE NO. 980698

Los Angeles Division

10235 BELLEGRAVE AVE.
 JURUPA VALLEY, CA 91752
 TEL: (909) 923-7668
 FAX: (909) 923-5015

© 2018 by YESCO LLC
 www.yesco.com
 All rights reserved.

CLIENT:



6100 WARNER AVE.
 HUNTINGTON BEACH, CA 92647

ACCOUNT EXECUTIVE:

JAY RESAR

DESIGN:

TORK

DATE:

10/30/17

REV./DATE/DESIGNER

R2 / TORK / 08/22/18
 Separated ground signs into it's own packet
 R3 / TORK / 11/02/18
 Added additional signs to complete branding book
 R4 / TORK / 11/14/18
 Revised per city comments

CUSTOMER APPROVAL:

- Accepted w/o changes
- Accepted w/ changes as noted
- Revise as noted & re-submit

SIGNATURE _____ DATE _____

PRODUCTION APPROVAL:

SALES EXECUTIVE _____ DATE _____

PRODUCTION MGR. _____ DATE _____

This drawing was created to assist you in visualizing our proposal. The original ideas herein are the property of YESCO SIGNS, LLC. Permission to copy or revise this drawing can only be obtained through a written agreement with YESCO. See your sales representative or call the nearest office of YESCO.

This sign is intended to be installed in accordance with the requirements of Article 600 of the National Electrical Code and/or other applicable local codes. This includes proper grounding and bonding of the sign.

Colors represented in this drawing are for presentation only. They cannot match actual processes being used on finished products. All salespersons can reference manufacturer's color charts at your request. Cost of providing necessary wiring to sign area is not included in this sign proposal.

PROJECT NUMBER:
 ART 01632 R4

SHEET:
 S12

Los Angeles Division

10235 BELLEGRAVE AVE.
JURUPA VALLEY, CA 91752
TEL: (909) 923-7668
FAX: (909) 923-5015

© 2018 by YESCO LLC
www.yesco.com
All rights reserved.

CLIENT:



6100 WARNER AVE.
HUNTINGTON BEACH, CA 92647

ACCOUNT EXECUTIVE:

JAY RESAR

DESIGN:

TORK

DATE:

10/30/17

REV./DATE/DESIGNER

R2 / TORK / 08/22/18
Separated ground signs into it's own packet
R3 / TORK / 11/02/18
Added additional signs to complete branding book
R4 / TORK / 11/14/18
Revised per city comments

CUSTOMER APPROVAL:

- Accepted w/o changes
- Accepted w/ changes as noted
- Revise as noted & re-submit

SIGNATURE _____ DATE _____

PRODUCTION APPROVAL:

SALES EXECUTIVE _____ DATE _____

PRODUCTION MGR. _____ DATE _____

This drawing was created to assist you in visualizing our proposal. The original ideas herein are the property of YESCO SIGNS, LLC. Permission to copy or revise this drawing can only be obtained through a written agreement with YESCO. See your sales representative or call the nearest office of YESCO.

This sign is intended to be installed in accordance with the requirements of Article 600 of the National Electrical Code and/or other applicable local codes. This includes proper grounding and bonding of the sign.





Colors represented in this drawing are for presentation only. They cannot match actual processes being used on finished products. All salespersons can reference manufacturer's color charts at your request. Cost of providing necessary wiring to sign area is not included in this sign proposal.

PROJECT NUMBER:

ART 01632 R4

SHEET:

S13

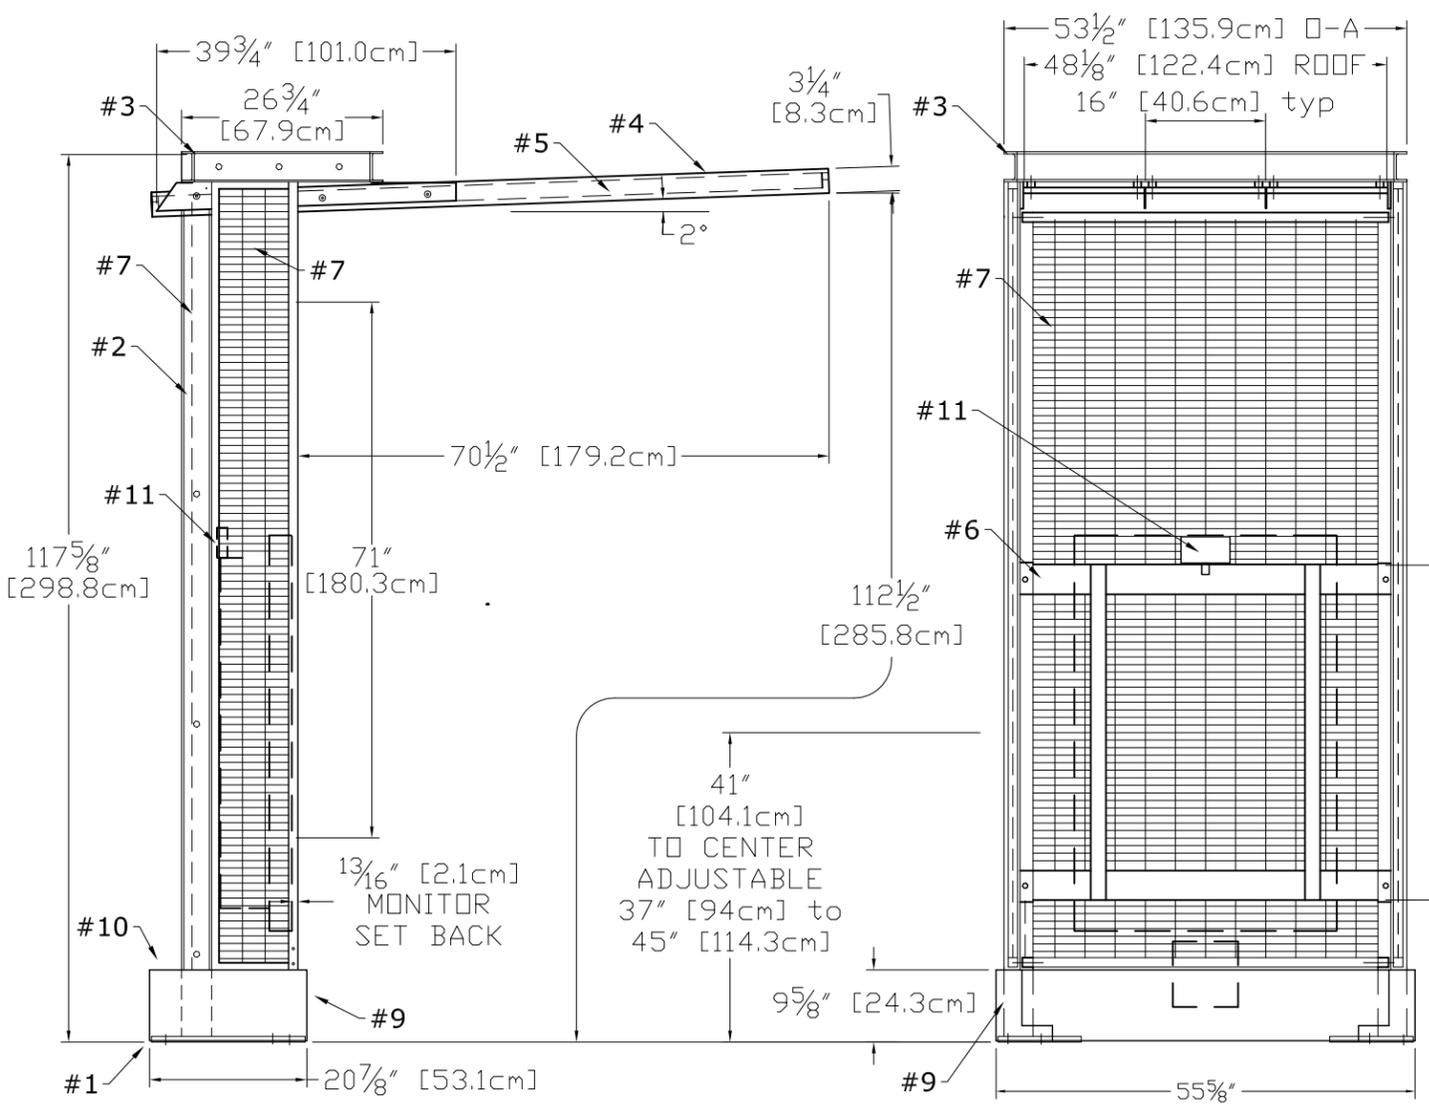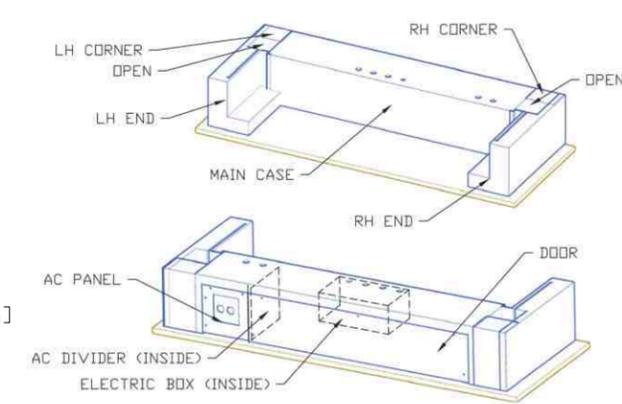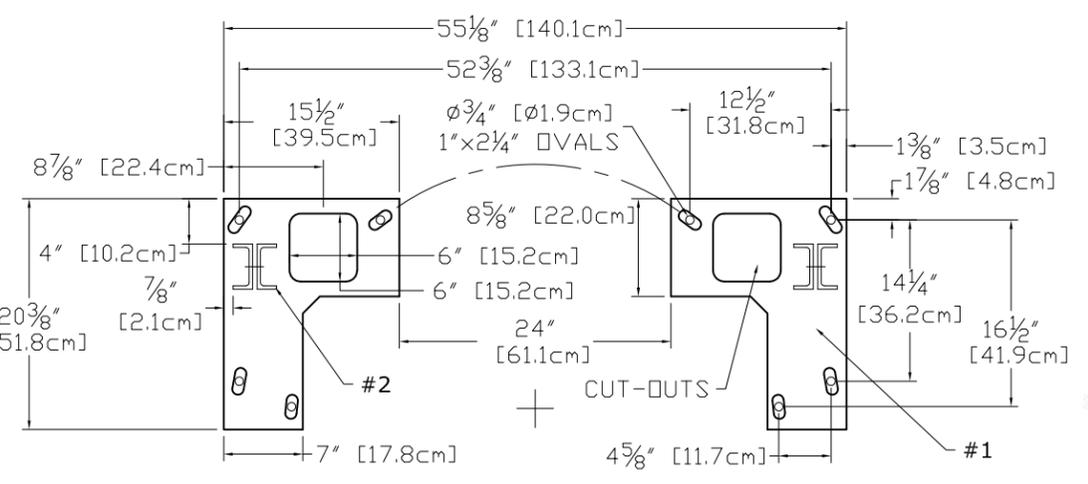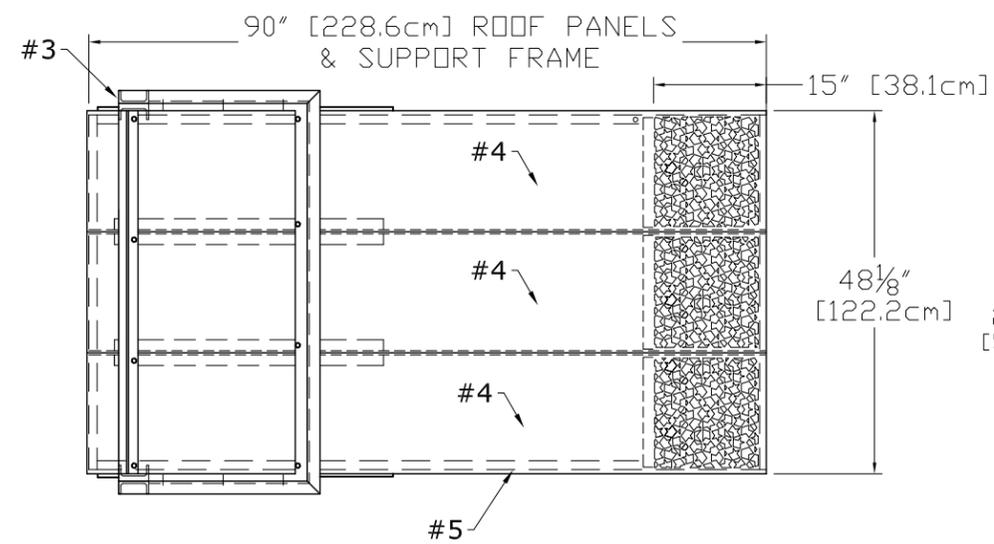

- #1 - TWO - 3/4" [19mm] STEEL BASE PLATES w/ OVAL HOLES FOR SWIVEL/POSITION 16 - 1/4" WASHERS SUPPLIED
- #2 - TWO - BACK TO BACK C4X7.25 (4"x1 3/4"x5 5/16") STEEL POSTS
- #3 - WELDED ALUMINUM HEADER, C4"X1.58" CHANNEL
- #4 - THREE - ALUMINUM ROOF PANELS SEAMLESS RAISED SIDE EDGES 15" OF LASERED PATTERN W/ DRIP EDGE BEHIND
- #5 - WELDED STEEL PERIMETER ROOF FRAME
- #6 - WELDED 3/16" STEEL [5mm] MONITOR SUPPORT FRAME WITH HGT ADJUSTMENT
- #7 - WELDED STEEL 1" [25.4mm] O-C WIRE GRID BACK & SIDE PANELS IN WELDED RECTANGULAR STEEL TUBE FRAMES
- #8 - N/A
- #9 - WELDED ALUMINUM BASE COVERS
- #10 - WELDED ALUMINUM WATER-TIGHT ELECTRIC ENCLOSURE (REAR HATCH)
- #11 - LED CEILING FLOODLIGHT, WIRED COMPLETE

DT ORDER POINT CANOPY FREESTANDING 14163
OPC, NO MONITOR OR ORDER BOARD

APPROVED 02/04/14



RAL7021 BLACK GREY, 10% SHEEN, EXT



NEW ORDER POINT CANOPY - FREESTANDING

QUANTITY: One (1) - Install Only. Manufactured by Others.

Design: 14163

Scale: 1/2" = 1'-0"

Los Angeles Division

10235 BELLEGRAVE AVE.
JURUPA VALLEY, CA 91752
TEL: (909) 923-7668
FAX: (909) 923-5015

© 2018 by YESCO LLC
www.yesco.com
All rights reserved.

CLIENT:



6100 WARNER AVE.
HUNTINGTON BEACH, CA 92647

ACCOUNT EXECUTIVE:

JAY RESAR

DESIGN:

TORK

DATE:

10/30/17

REV./DATE/DESIGNER

R2 / TORK / 08/22/18
Separated ground signs into it's own packet
R3 / TORK / 11/02/18
Added additional signs to complete branding book
R4 / TORK / 11/14/18
Revised per city comments

CUSTOMER APPROVAL:

- Accepted w/o changes
- Accepted w/ changes as noted
- Revise as noted & re-submit

SIGNATURE _____ DATE _____

PRODUCTION APPROVAL:

SALES EXECUTIVE _____ DATE _____

PRODUCTION MGR. _____ DATE _____

This drawing was created to assist you in visualizing our proposal. The original ideas herein are the property of YESCO SIGNS, LLC. Permission to copy or revise this drawing can only be obtained through a written agreement with YESCO. See your sales representative or call the nearest office of YESCO.

This sign is intended to be installed in accordance with the requirements of Article 600 of the National Electrical Code and/or other applicable local codes. This includes proper grounding and bonding of the sign.






Colors represented in this drawing are for presentation only. They cannot match actual processes being used on finished products. All salespersons can reference manufacturer's color charts at your request. Cost of providing necessary wiring to sign area is not included in this sign proposal.

PROJECT NUMBER:



ART 01632 R4

SHEET:

S14

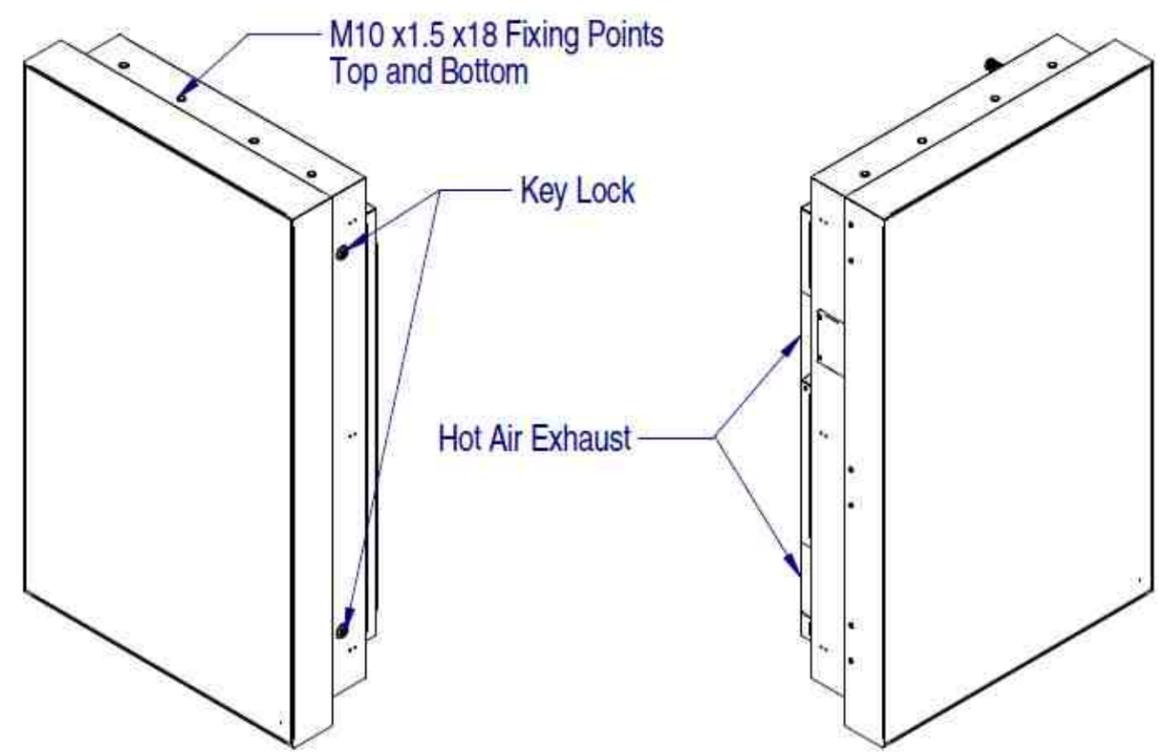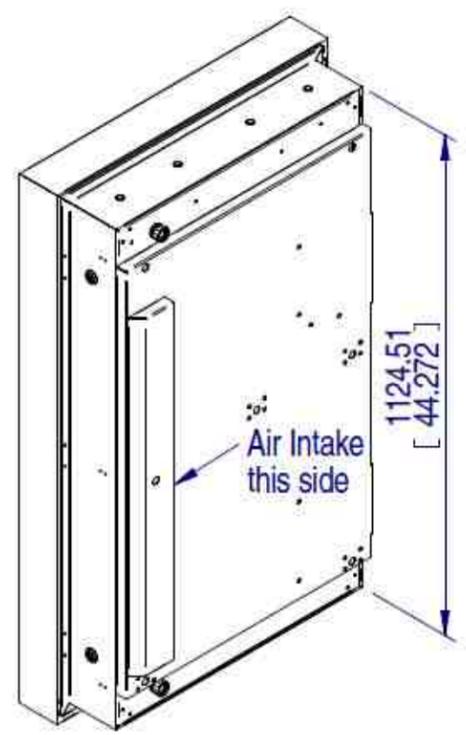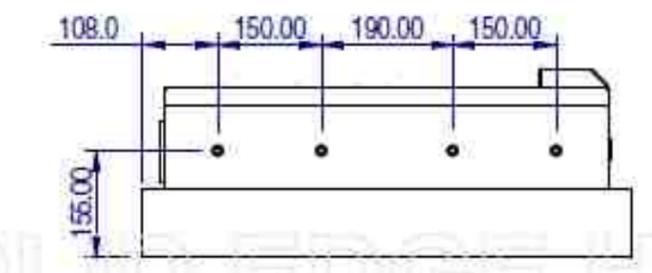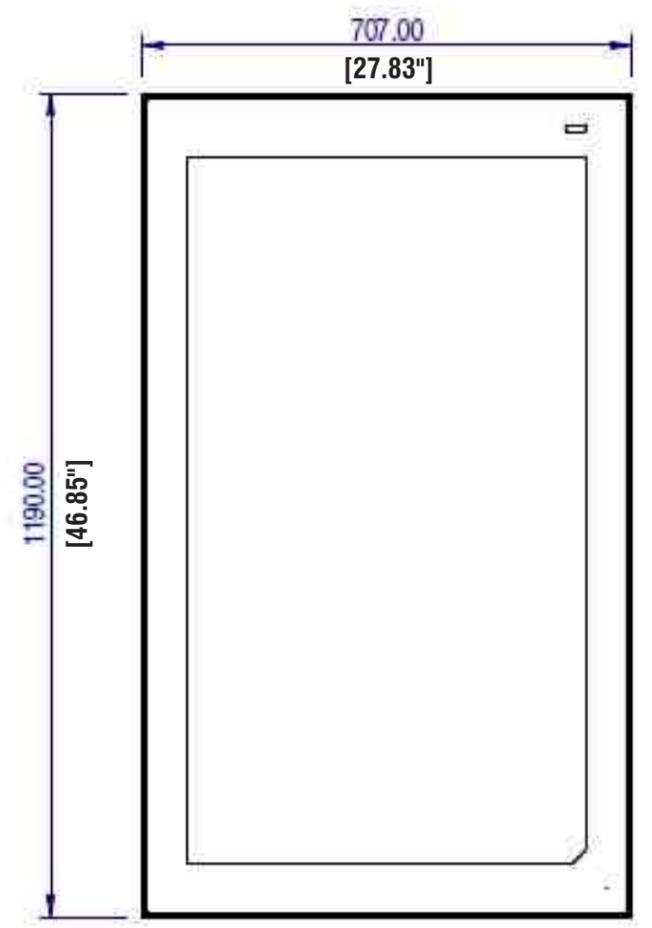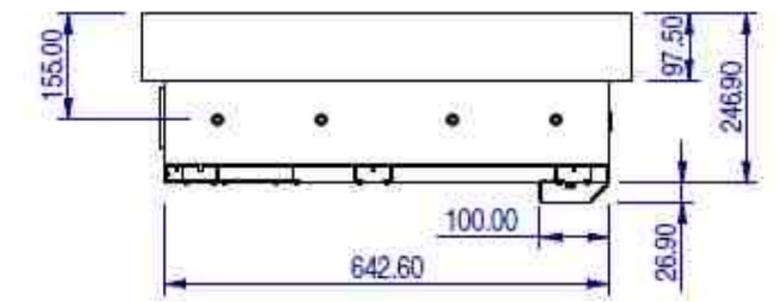

STARBUCKS COFFEE LETTERS NOT INCLUDED IN PROPOSED CANOPY

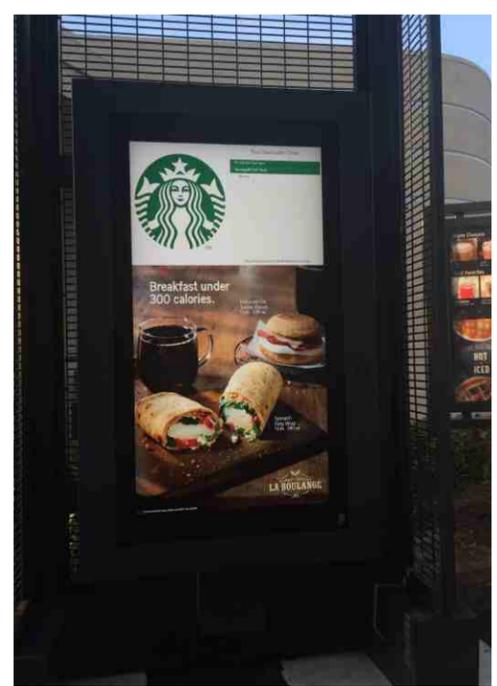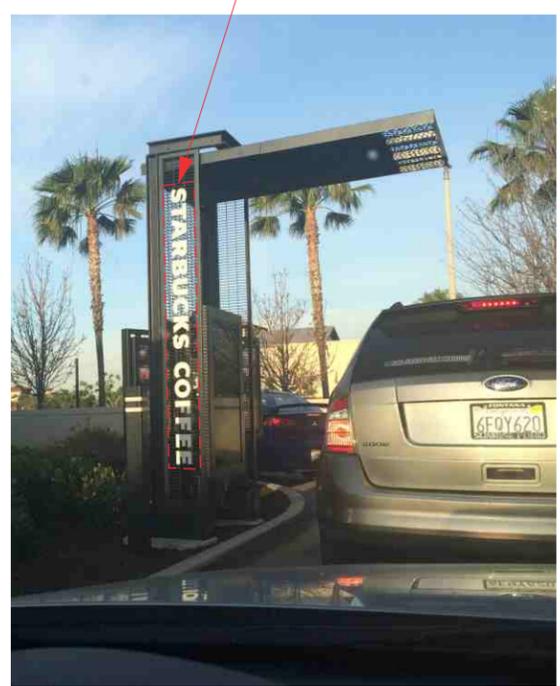

PHOTO'S OF TYPICAL FREESTANDING CANOPY WITH ORDER POINT SCREEN



Los Angeles Division

10235 BELLEGRAVE AVE.
JURUPA VALLEY, CA 91752
TEL: (909) 923-7668
FAX: (909) 923-5015

© 2018 by YESCO LLC
www.yesco.com
All rights reserved.

CLIENT:



6100 WARNER AVE.
HUNTINGTON BEACH, CA 92647

ACCOUNT EXECUTIVE:

JAY RESAR

DESIGN:

TORK

DATE:

10/30/17

REV./DATE/DESIGNER

R2 / TORK / 08/22/18
Separated ground signs into it's own packet
R3 / TORK / 11/02/18
Added additional signs to complete branding book
R4 / TORK / 11/14/18
Revised per city comments

CUSTOMER APPROVAL:

- Accepted w/o changes
- Accepted w/ changes as noted
- Revise as noted & re-submit

SIGNATURE _____ DATE _____

PRODUCTION APPROVAL:

SALES EXECUTIVE _____ DATE _____

PRODUCTION MGR. _____ DATE _____

This drawing was created to assist you in visualizing our proposal. The original ideas herein are the property of YESCO SIGNS, LLC. Permission to copy or revise this drawing can only be obtained through a written agreement with YESCO. See your sales representative or call the nearest office of YESCO.

This sign is intended to be installed in accordance with the requirements of Article 600 of the National Electrical Code and/or other applicable local codes. This includes proper grounding and bonding of the sign.





Colors represented in this drawing are for presentation only. They cannot match actual processes being used on finished products. All salespersons can reference manufacturer's color charts at your request. Cost of providing necessary wiring to sign area is not included in this sign proposal.

PROJECT NUMBER:

ART 01632 R4

SHEET:

S15

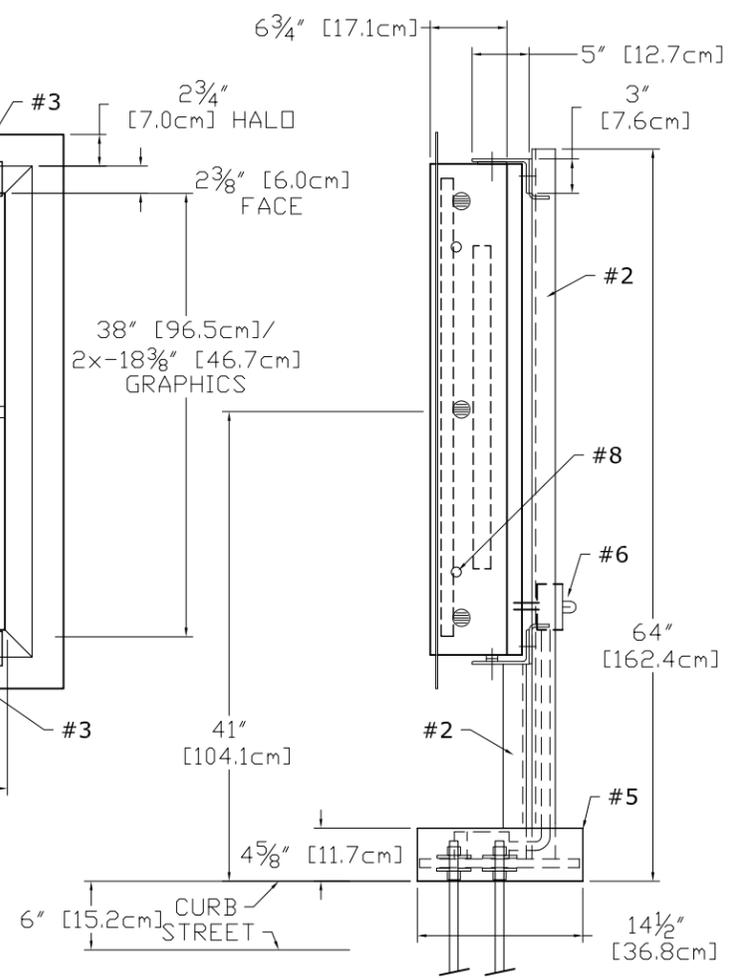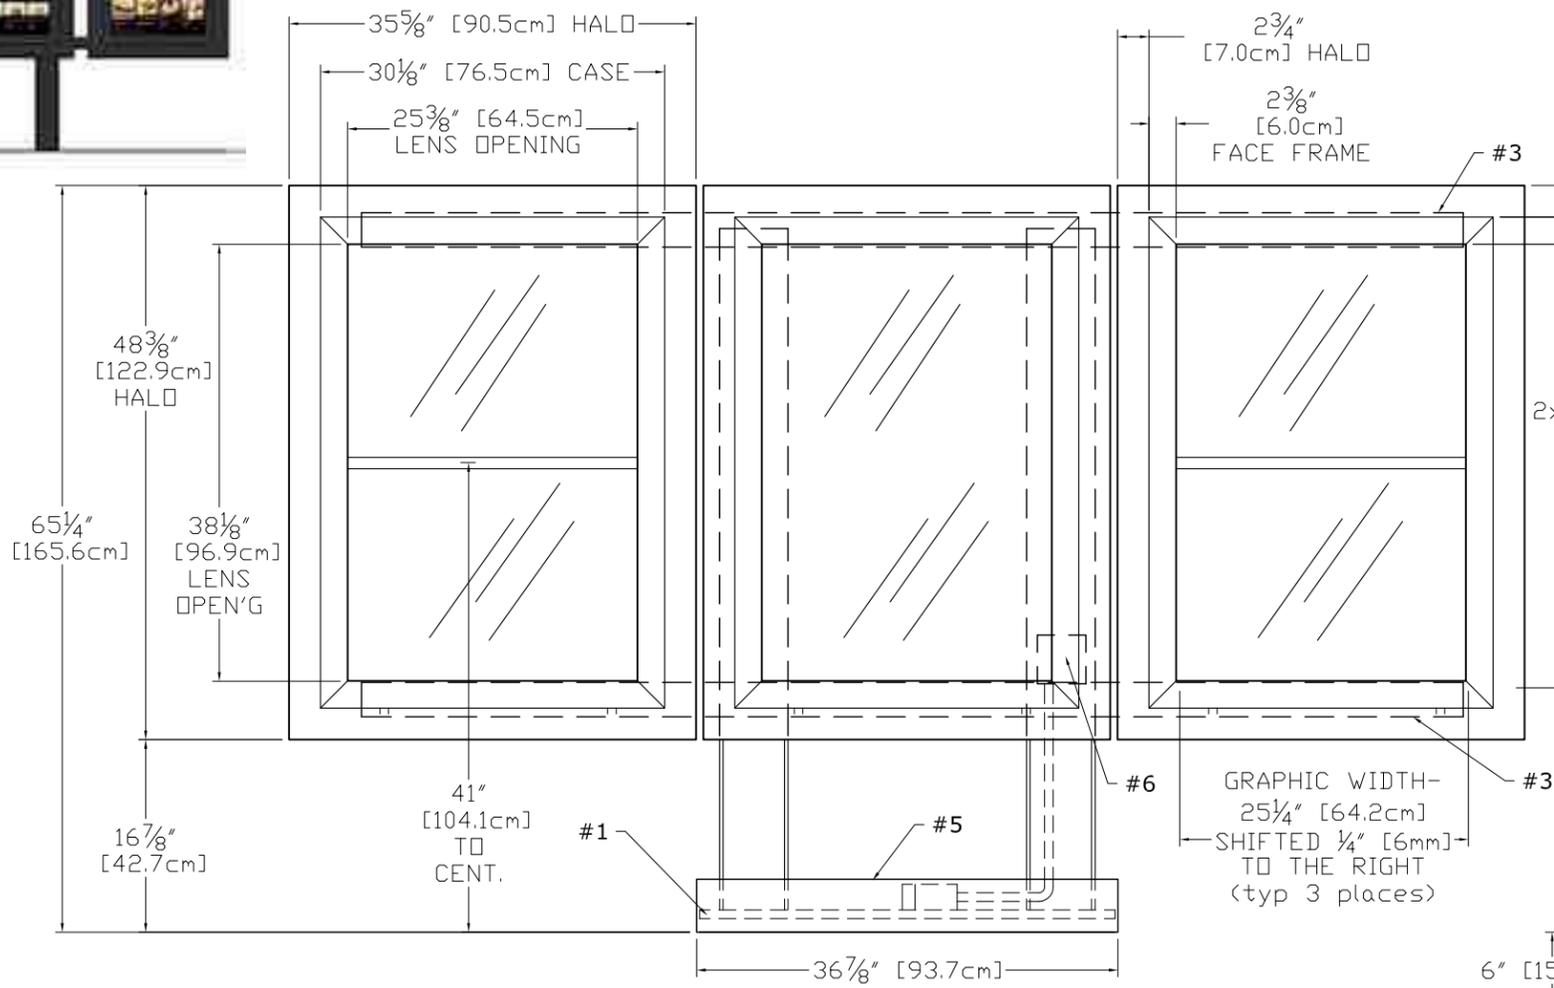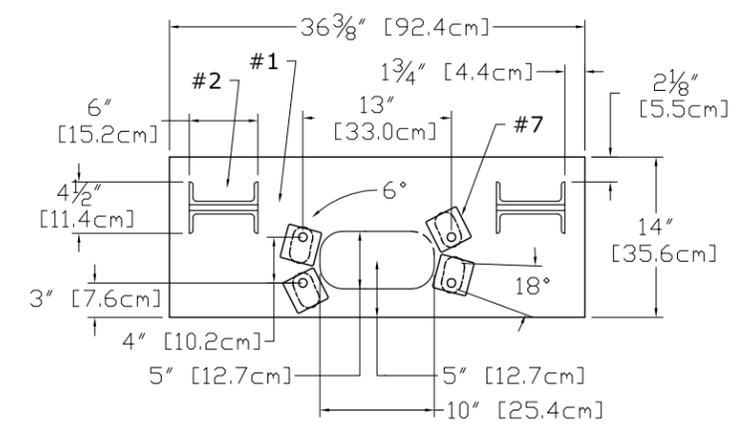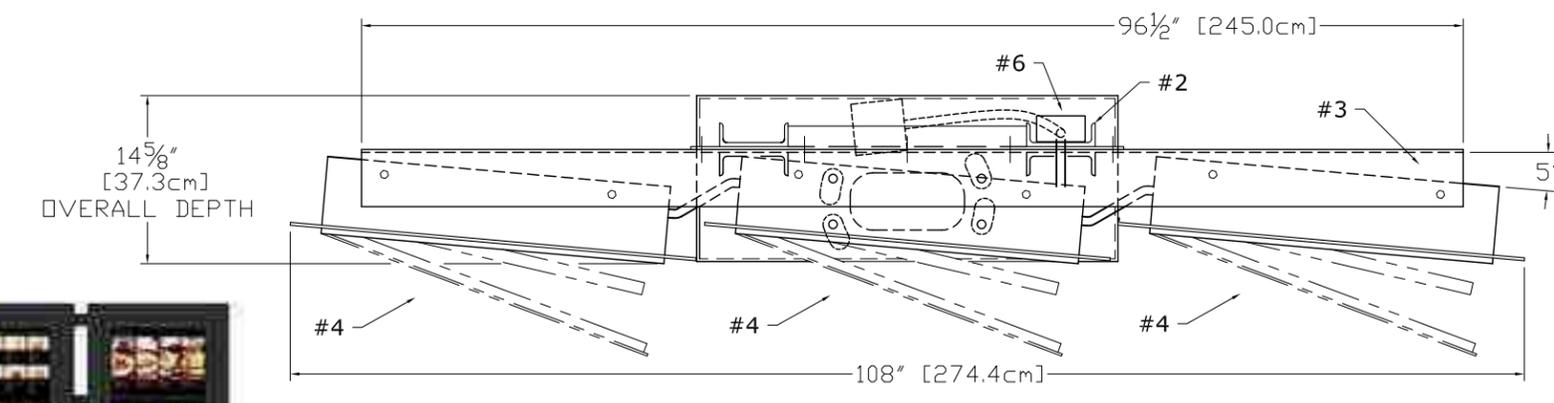

- #1 - 3/4" [19mm] STEEL BASE PLATE w/ 18deg HOLES PATTERN ROTATED FOR 15deg THRU 3deg POSITION
- #2 - C6X10.5 (6"x2"x5 1/16") STEEL POST (2x)
- #3 - 5"x3"x1/4" STEEL SUPPORT ANGLES (2x) (BOLTED TO WELDED 1/4" STEEL CROSSBARS)
- #4 - EXTRUDED ALUMINUM MENU BOARDS (3x) ONE FULL AND TWO SPLIT PANEL LIGHTBOXES ONE - 25 1/4"x38" AND FOUR 25 1/4"x18 3/8" GRAPHICS ALL GRAPHIC ASSEMBLIES SHIFTED 1/4" TO RIGHT STANDARD LED TUBE LIGHTING, SIDE LOCKS

- #5 - WELDED ALUMINUM BASE COVER
- #6 - WATER-TIGHT BOX w/SWITCH & SENSOR, RIDGID CONDUIT RUN TO SECOND EXT BOX BELOW BASE COVER, 120 WATT, 0.90Ac
- #7 - 8 BASE WASHERS, 1/4" THICK
- #8 - TWO SIDE MOUNT LOCKS per MENUBOARD RETAIN EXISTING KEY #E3-26-819-15



NEW 5-PANEL MENU FREESTANDING SIGN

QUANTITY: One (1) - Install Only. Manufactured by DSA Phototech.

Design: 14119

Scale: 3/4" = 1'-0"

APPROVED
02/06/14

DT 5 PANEL FREESTANDING		14119	11036585
<small>ALL DESIGN, OPERATIVE AND PROCESS DATA PERTAINING TO THE ARTICLE SHOWN ON THIS SHEET IS THE PROPERTY OF DSA PHOTOTECH. IT IS DISCLOSED IN CONFIDENCE AND IS NOT TO BE COPIED, REPRODUCED, REVEALED TO, OR APPROPRIATED BY OTHERS, IN PART OR IN WHOLE, WITHOUT THE EXPRESS CONSENT OF DSA PHOTOTECH. THIS PRINT IS LOANED AND MUST NOT BE USED IN ANY MANNER DETRIMENTAL TO THE INTEREST OF DSA PHOTOTECH.</small>		DSA/PHOTOTECH 16961 Central Avenue, Carson, CA 90746 (310) 537-5000 (310) 537-7060 Fax phubbell@dsaphototech.com	
		DRIVE THRU 5 PANEL w/ STAND	
PAH	DATE 02/06/14	CQSBEDT5LED	SCALE 1 : 20 SHT 1 OF 1